

© This Drawing is the copyright of benjamin + beauchamp architects ltd.


All dimensions to be checked on site by contractor and not scaled from this drawing.

benjamin + beauchamp architects ltd accept no liability for any expense, loss or damage of whatsoever nature and however arising; from any variation made to this drawing; or in the execution of the work to which it relates, which has not been referred to them and their approval obtained.

p:\glastonbury - st benedicts - 0875\drawings, photos & graphics\b2 drawings\drawing board\0875.p.009 proposed heating plan.dwg

0875.P.009

## **DRAFT**

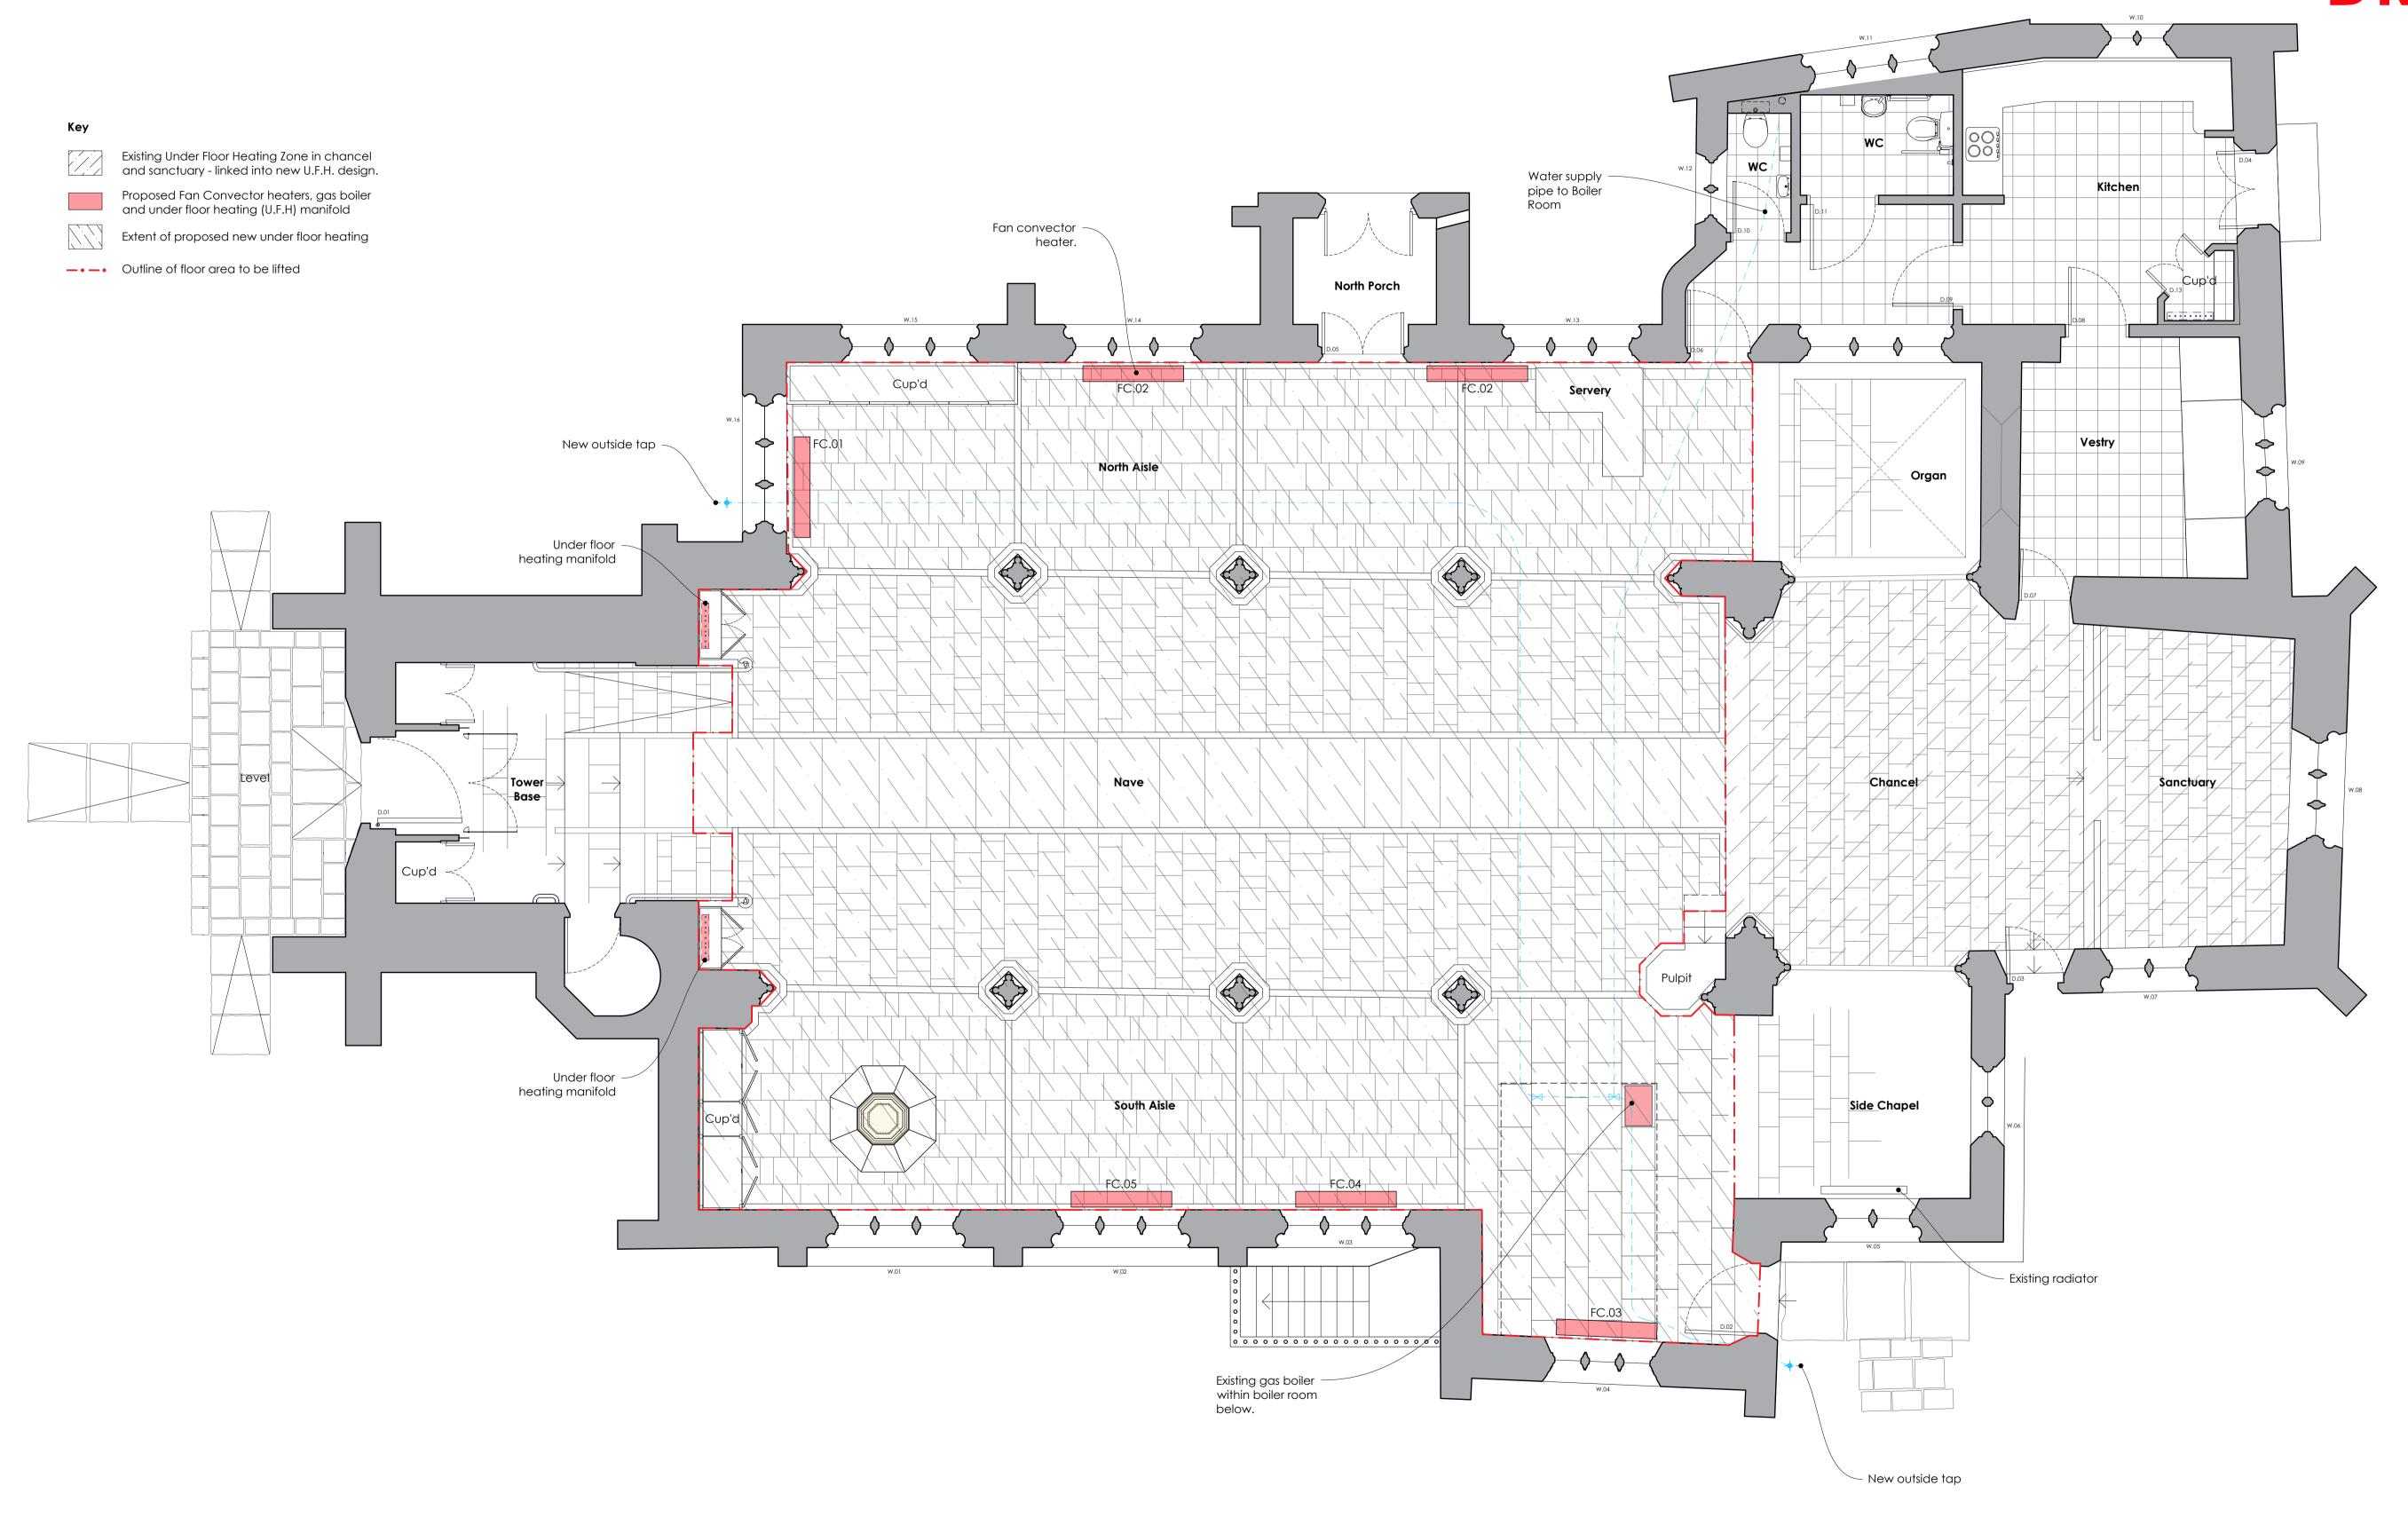



GLASTONBURY, St Benedict's	Stage Proposed	Drawing
TITLE	Proposed  Drawn By Date Scale	
Proposed Heating Floor Plan	JLB 16/07/24 1:50 at A1 Revision Date Initials Notes	8.7