




LED recessed downlight 12W
ultra-thin (10mm installation) warm
white (3000k) 300mmØ



MLS 2x LED linear strip in warm white

NOTE:
Rooflight omitted since planning stage therefore no light spill shall be created upwards onto the tower. No new external lighting is proposed.

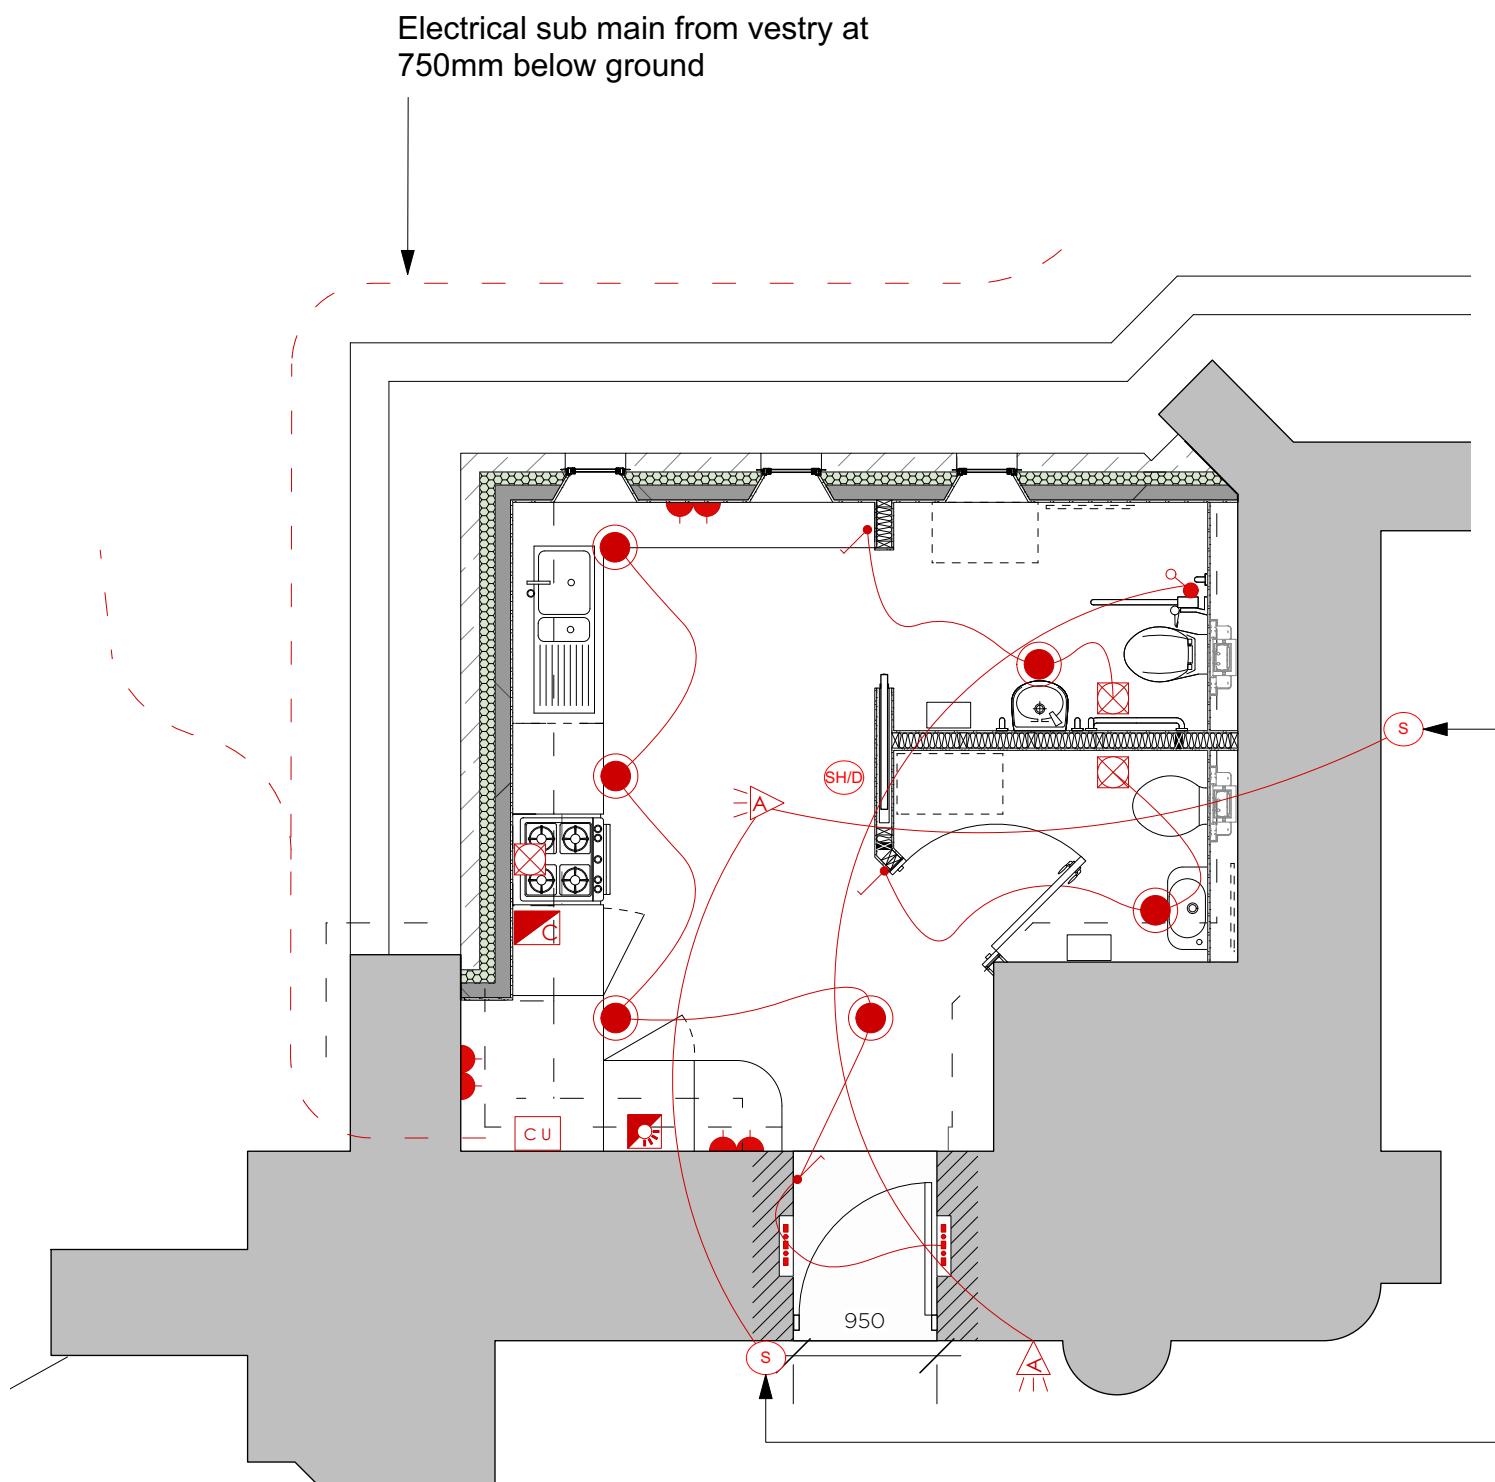

LIGHTING AND ELECTRICAL KEY


●	FIXED RECESSED CEILING FITTING
---	LED STRING
●	LIGHT SWITCH
CU	CONSUMER UNIT
SH/D	MAINS WIRED SMOKE & HEAT DETECTOR
S	MAINS WIRED SMOKE DETECTOR
●	EMERGENCY PULL CHORD
A	AUDIO AND VISUAL EMERGENCY ALARM
CE	CEILING FIXED MECHANICAL EXTRACTOR
SW	SWITCHED FUSED SPUR WITH LIT INDICATOR
30A	30AMP COOKER FUSED SPUR
HL	HIGH LEVEL WALL MOUNT TWIN SOCKET

AMENDMENT:

A - Smoke detectors and alarm added

DATE:

 11/09/2025



Status	Planning & Listed Building Application		
Job no / drawing no	Job title		
571-L-16A	St Julians, Wellow		
Drawing title			
Proposed Electrical Layout			
Date	Sheet	Scale	Drawn by
02.09.2025	A3	1:50	JS
Checked by			
JH			
All dimensions to be checked on site. Print Drawing in colour. Refer to CDM Sheet XXX/CDM			
www.hetreedross.com 01225 755867			
Do not scale			