


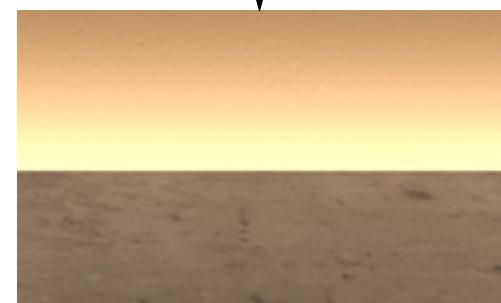


LED recessed downlight 12W
ultra-thin (10mm installation) warm
white (3000k) 300mmØ



MLS 2x LED linear strip in warm white

NOTE:
Rooflight omitted since planning stage therefore no light
spill shall be created upwards onto the tower. No new
external lighting is proposed.

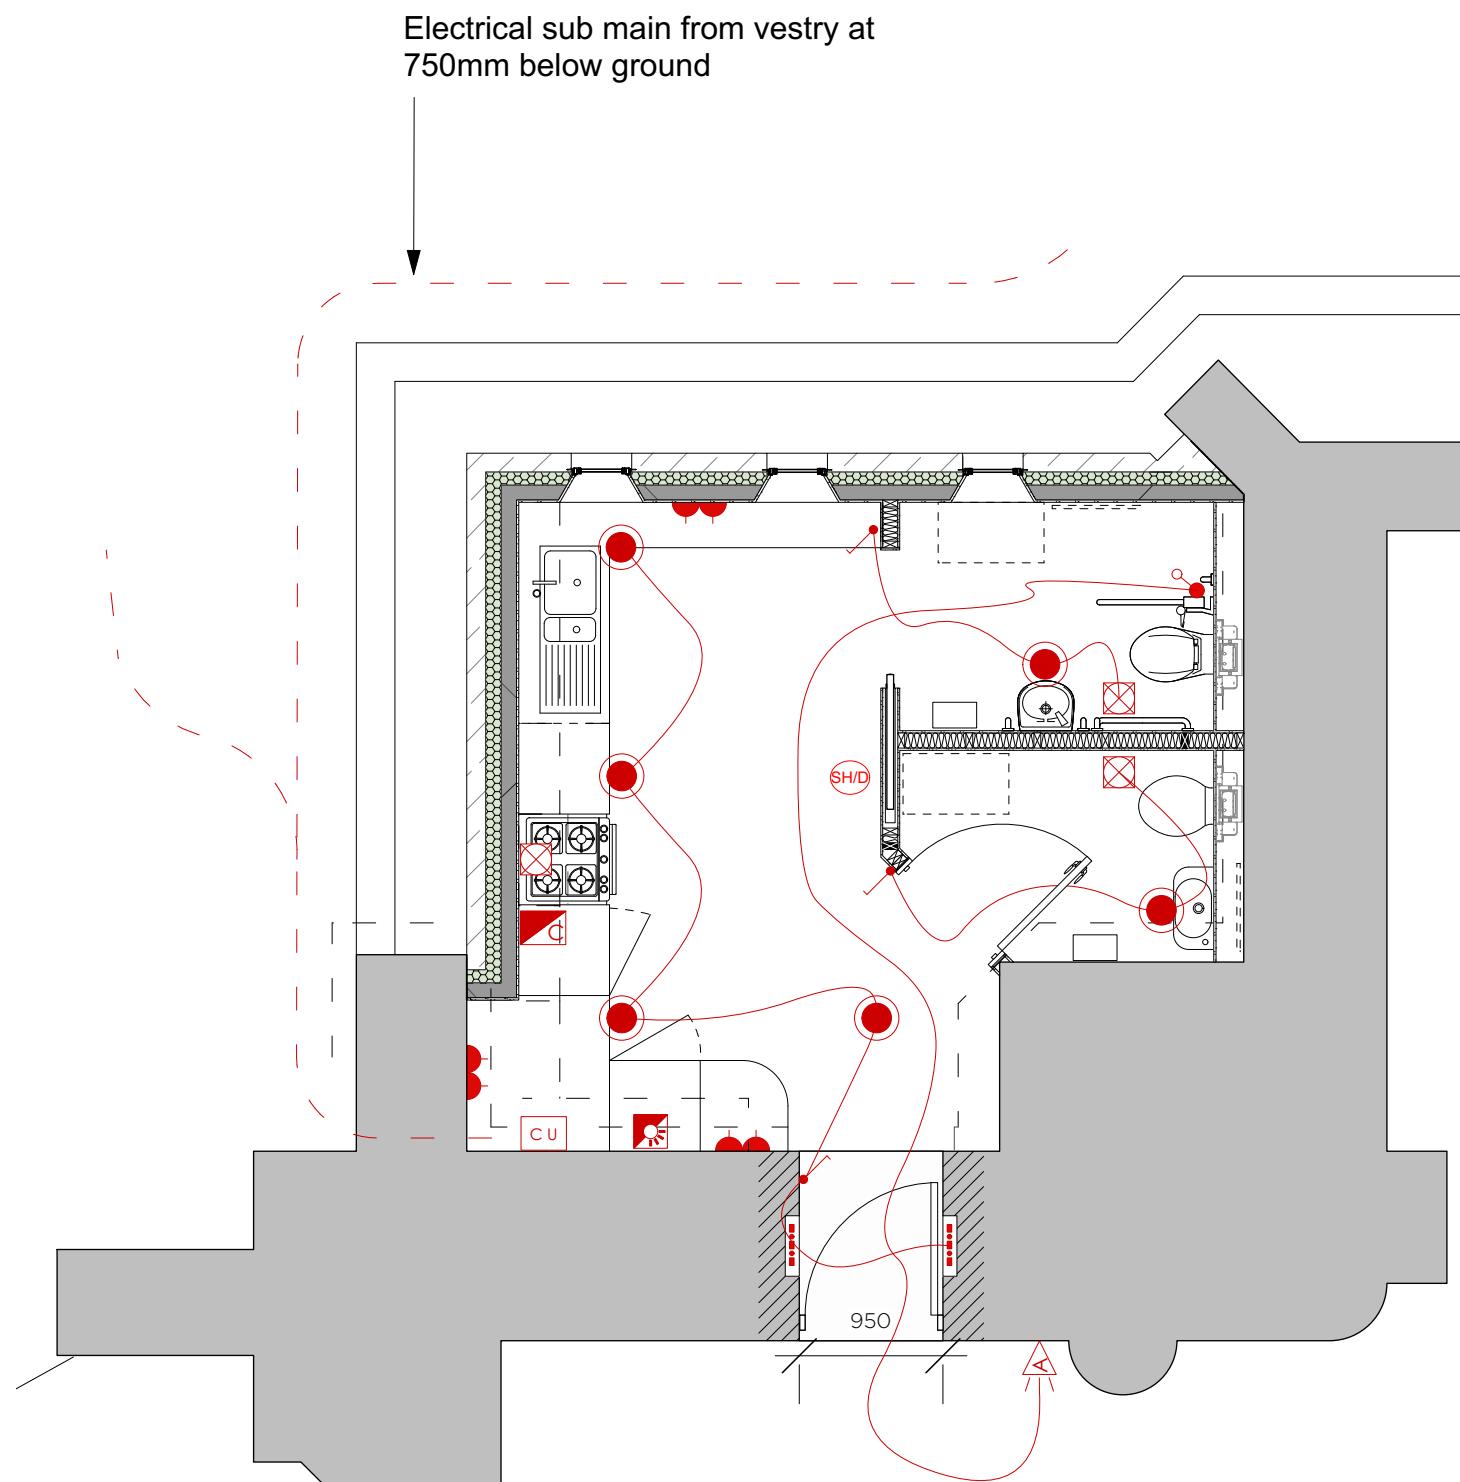

AMENDMENT:

DATE:

Status	Planning & Listed Building Application	
Job no / drawing no	Job title	
571-L-16	St Julians, Wellow	
Drawing title		
Proposed Electrical Layout		
Date	Sheet	Scale
02.09.2025	A3	1:50
Drawn by		Checked by
JS		JH
All dimensions to be checked on site. Print Drawing in colour. Refer to CDM Sheet XXX/CDM		
www.hetreedross.com 01225 755867		
Do not scale		

