

Status	Planning & Listed Building Application			
Job no / drawing no	Job title			
571-L-15	St Julians, Wellow			
Drawing title				
Proposed Tower Door Details				
Date	Sheet	Scale	Drawn by	Checked by
02.09.2025	A3	1:20	JS	JH
All dimensions to be checked on site. Print Drawing in colour. Refer to CDM Sheet XXX/CDM				


0 0.2 0.4 0.6 0.8
1:20 METRES

hetreed ross architects
hra
www.hetreedross.com 01225 755867

Do not scale




LED recessed downlight 12W
ultra-thin (10mm installation) warm
white (3000k) 300mmØ

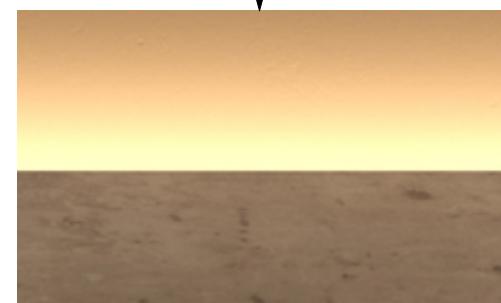

MLS 2x LED linear strip in warm white


NOTE:
Rooflight omitted since planning stage therefore no light spill shall be created upwards onto the tower. No new external lighting is proposed.

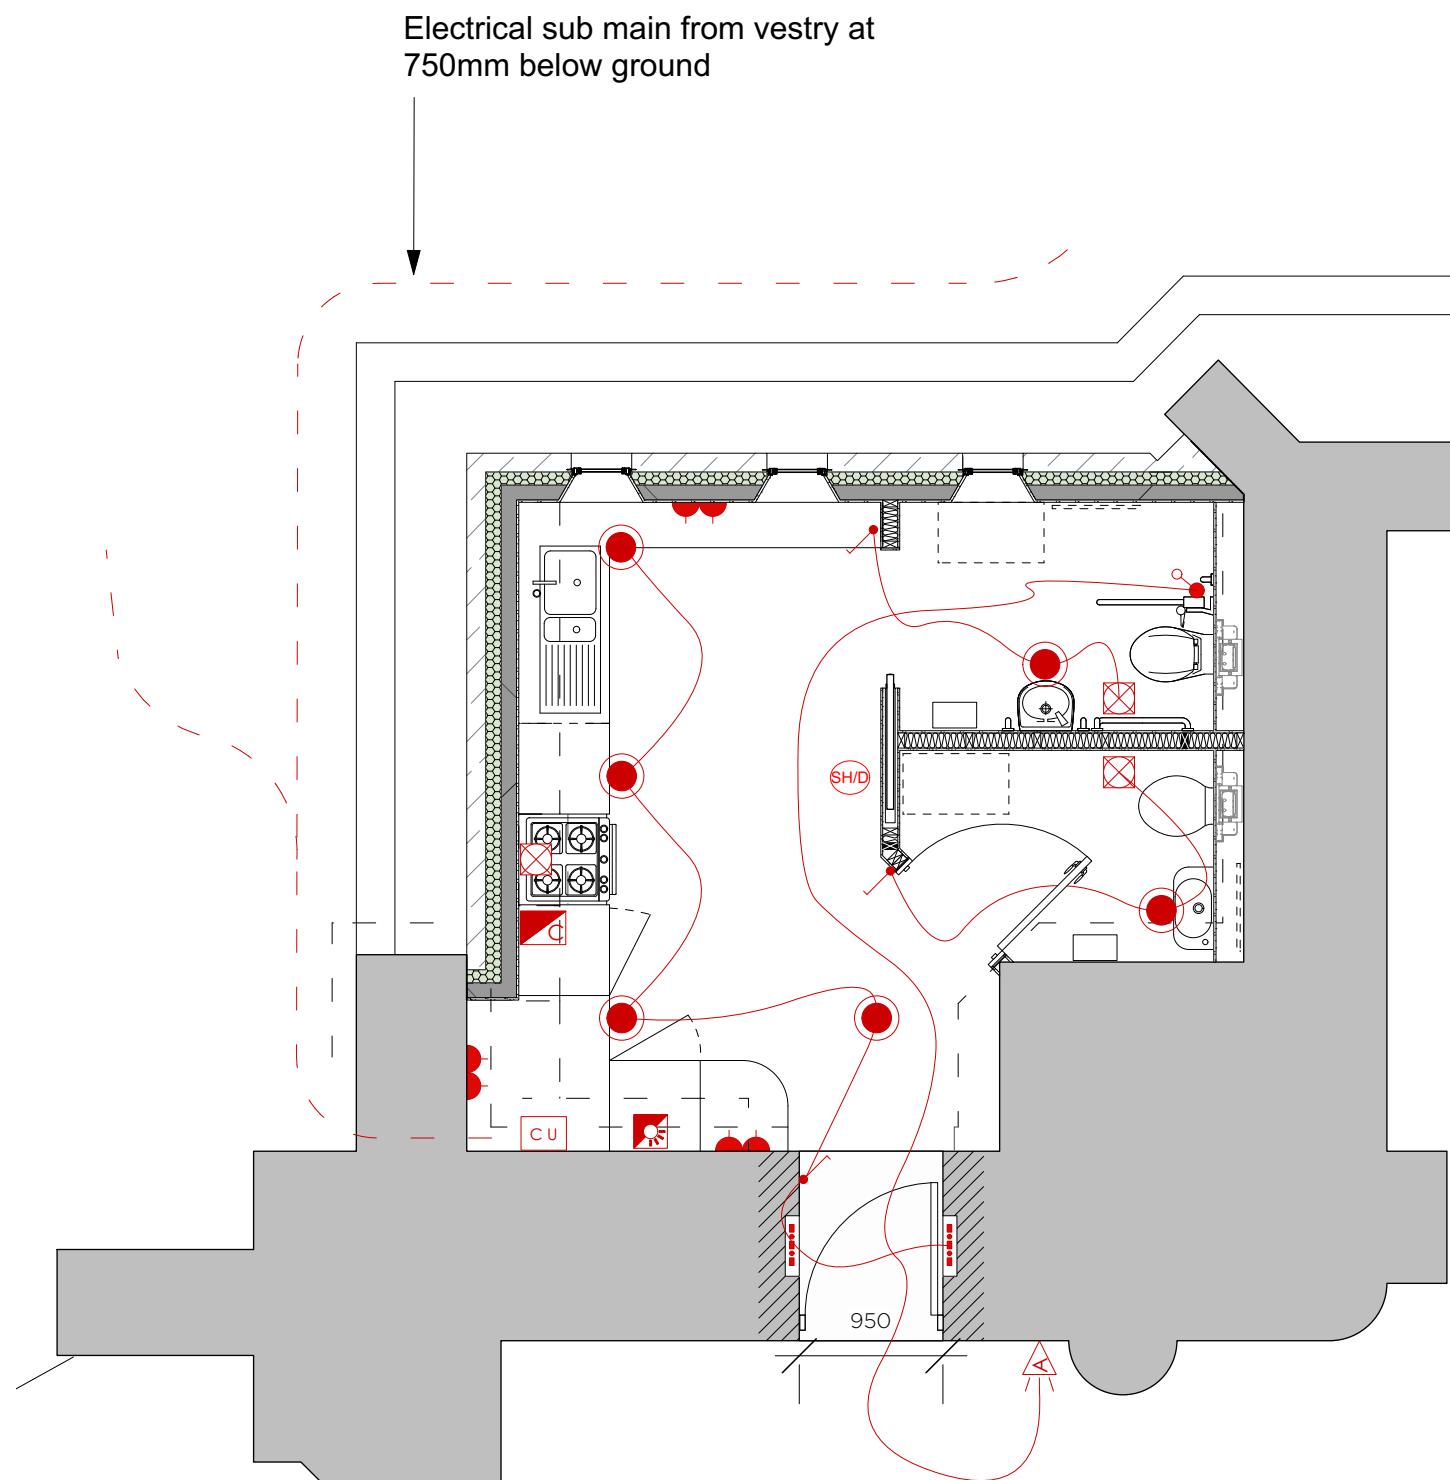


AMENDMENT:

DATE:

Status	Planning & Listed Building Application		
Job no / drawing no	Job title		
571-L-16	St Julians, Wellow		
Drawing title			
Proposed Electrical Layout			
Date	Sheet	Scale	Drawn by
02.09.2025	A3	1:50	JS
Checked by			
JH			
All dimensions to be checked on site. Print Drawing in colour. Refer to CDM Sheet XXX/CDM			
www.hetreedross.com 01225 755867			
Do not scale			

 

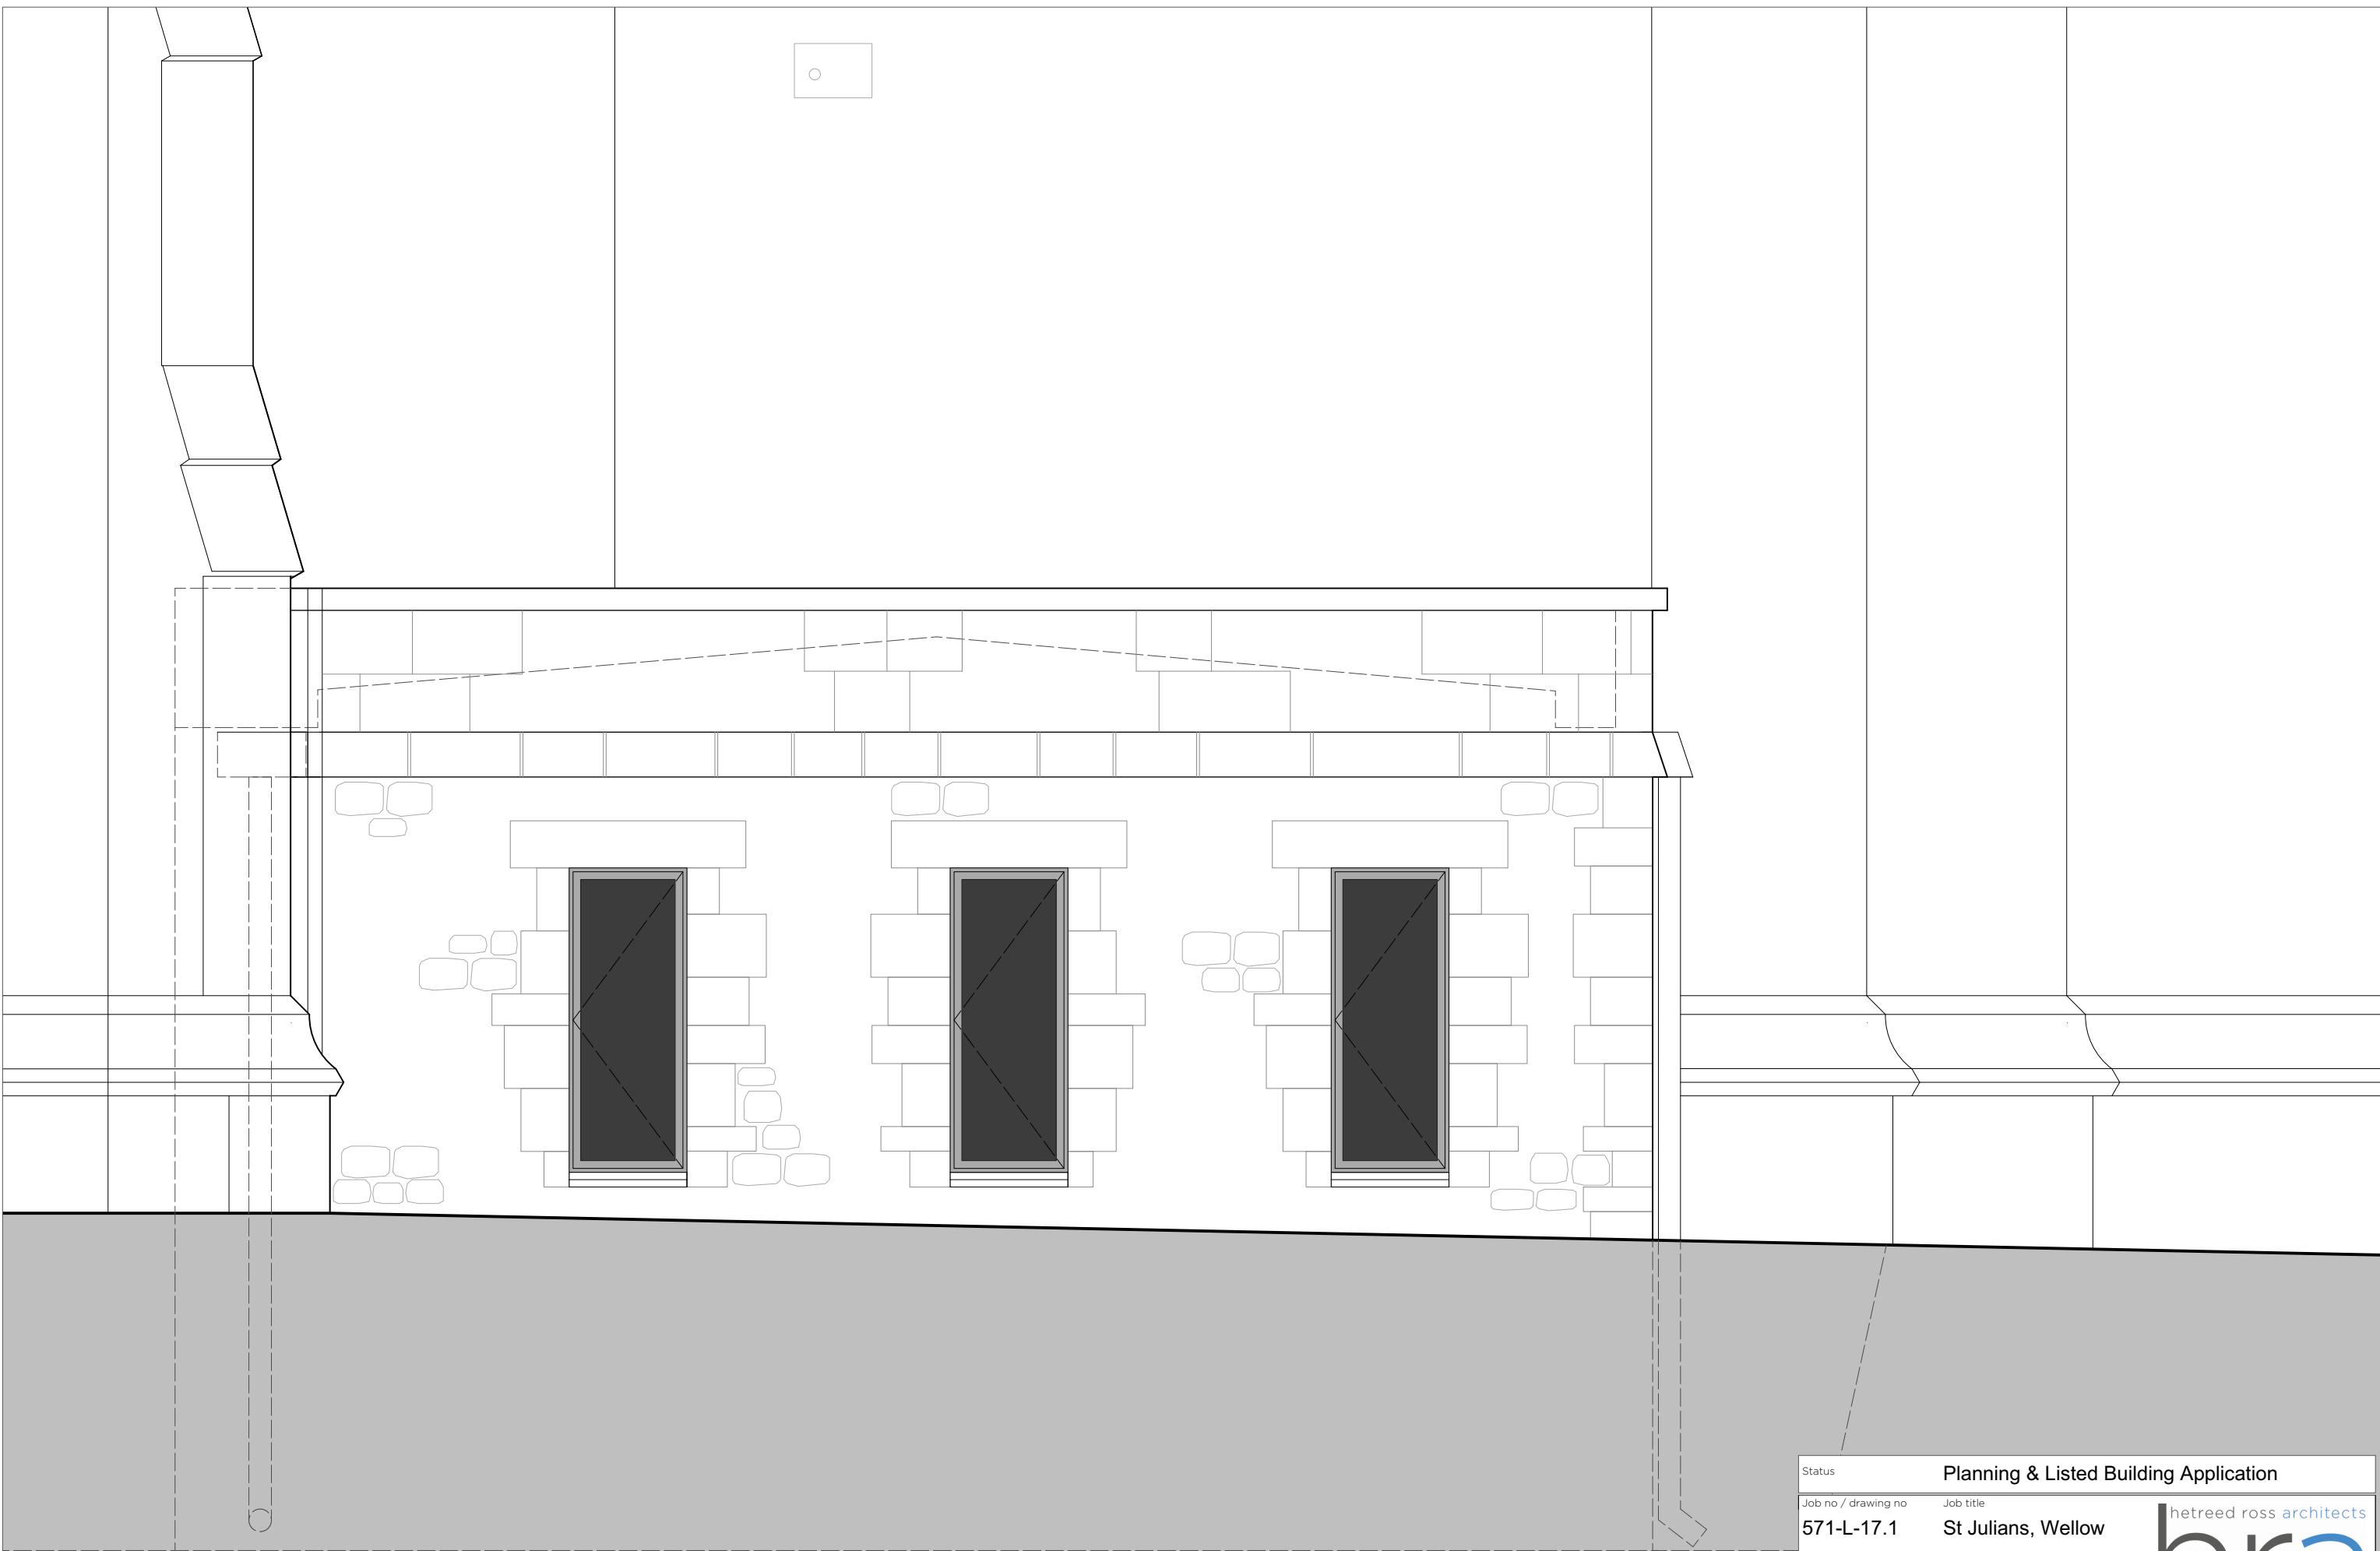




Proposed North Elevation

Scale 1:20

0 0.2 0.4 0.6 0.8
1:20 METRES

Status	Planning & Listed Building Application		
Job no / drawing no	Job title		
571-L-17.1	St Julians, Wellow		
Drawing title			
Proposed Detail Elevations (North)			
Date	Sheet	Scale	Drawn by
02.09.2025	A3	1:20	JS
Checked by			
JH			
All dimensions to be checked on site. Print Drawing in colour. Refer to CDM Sheet XXX/CDM			
www.hetreedross.com 01225 755867			
Do not scale			

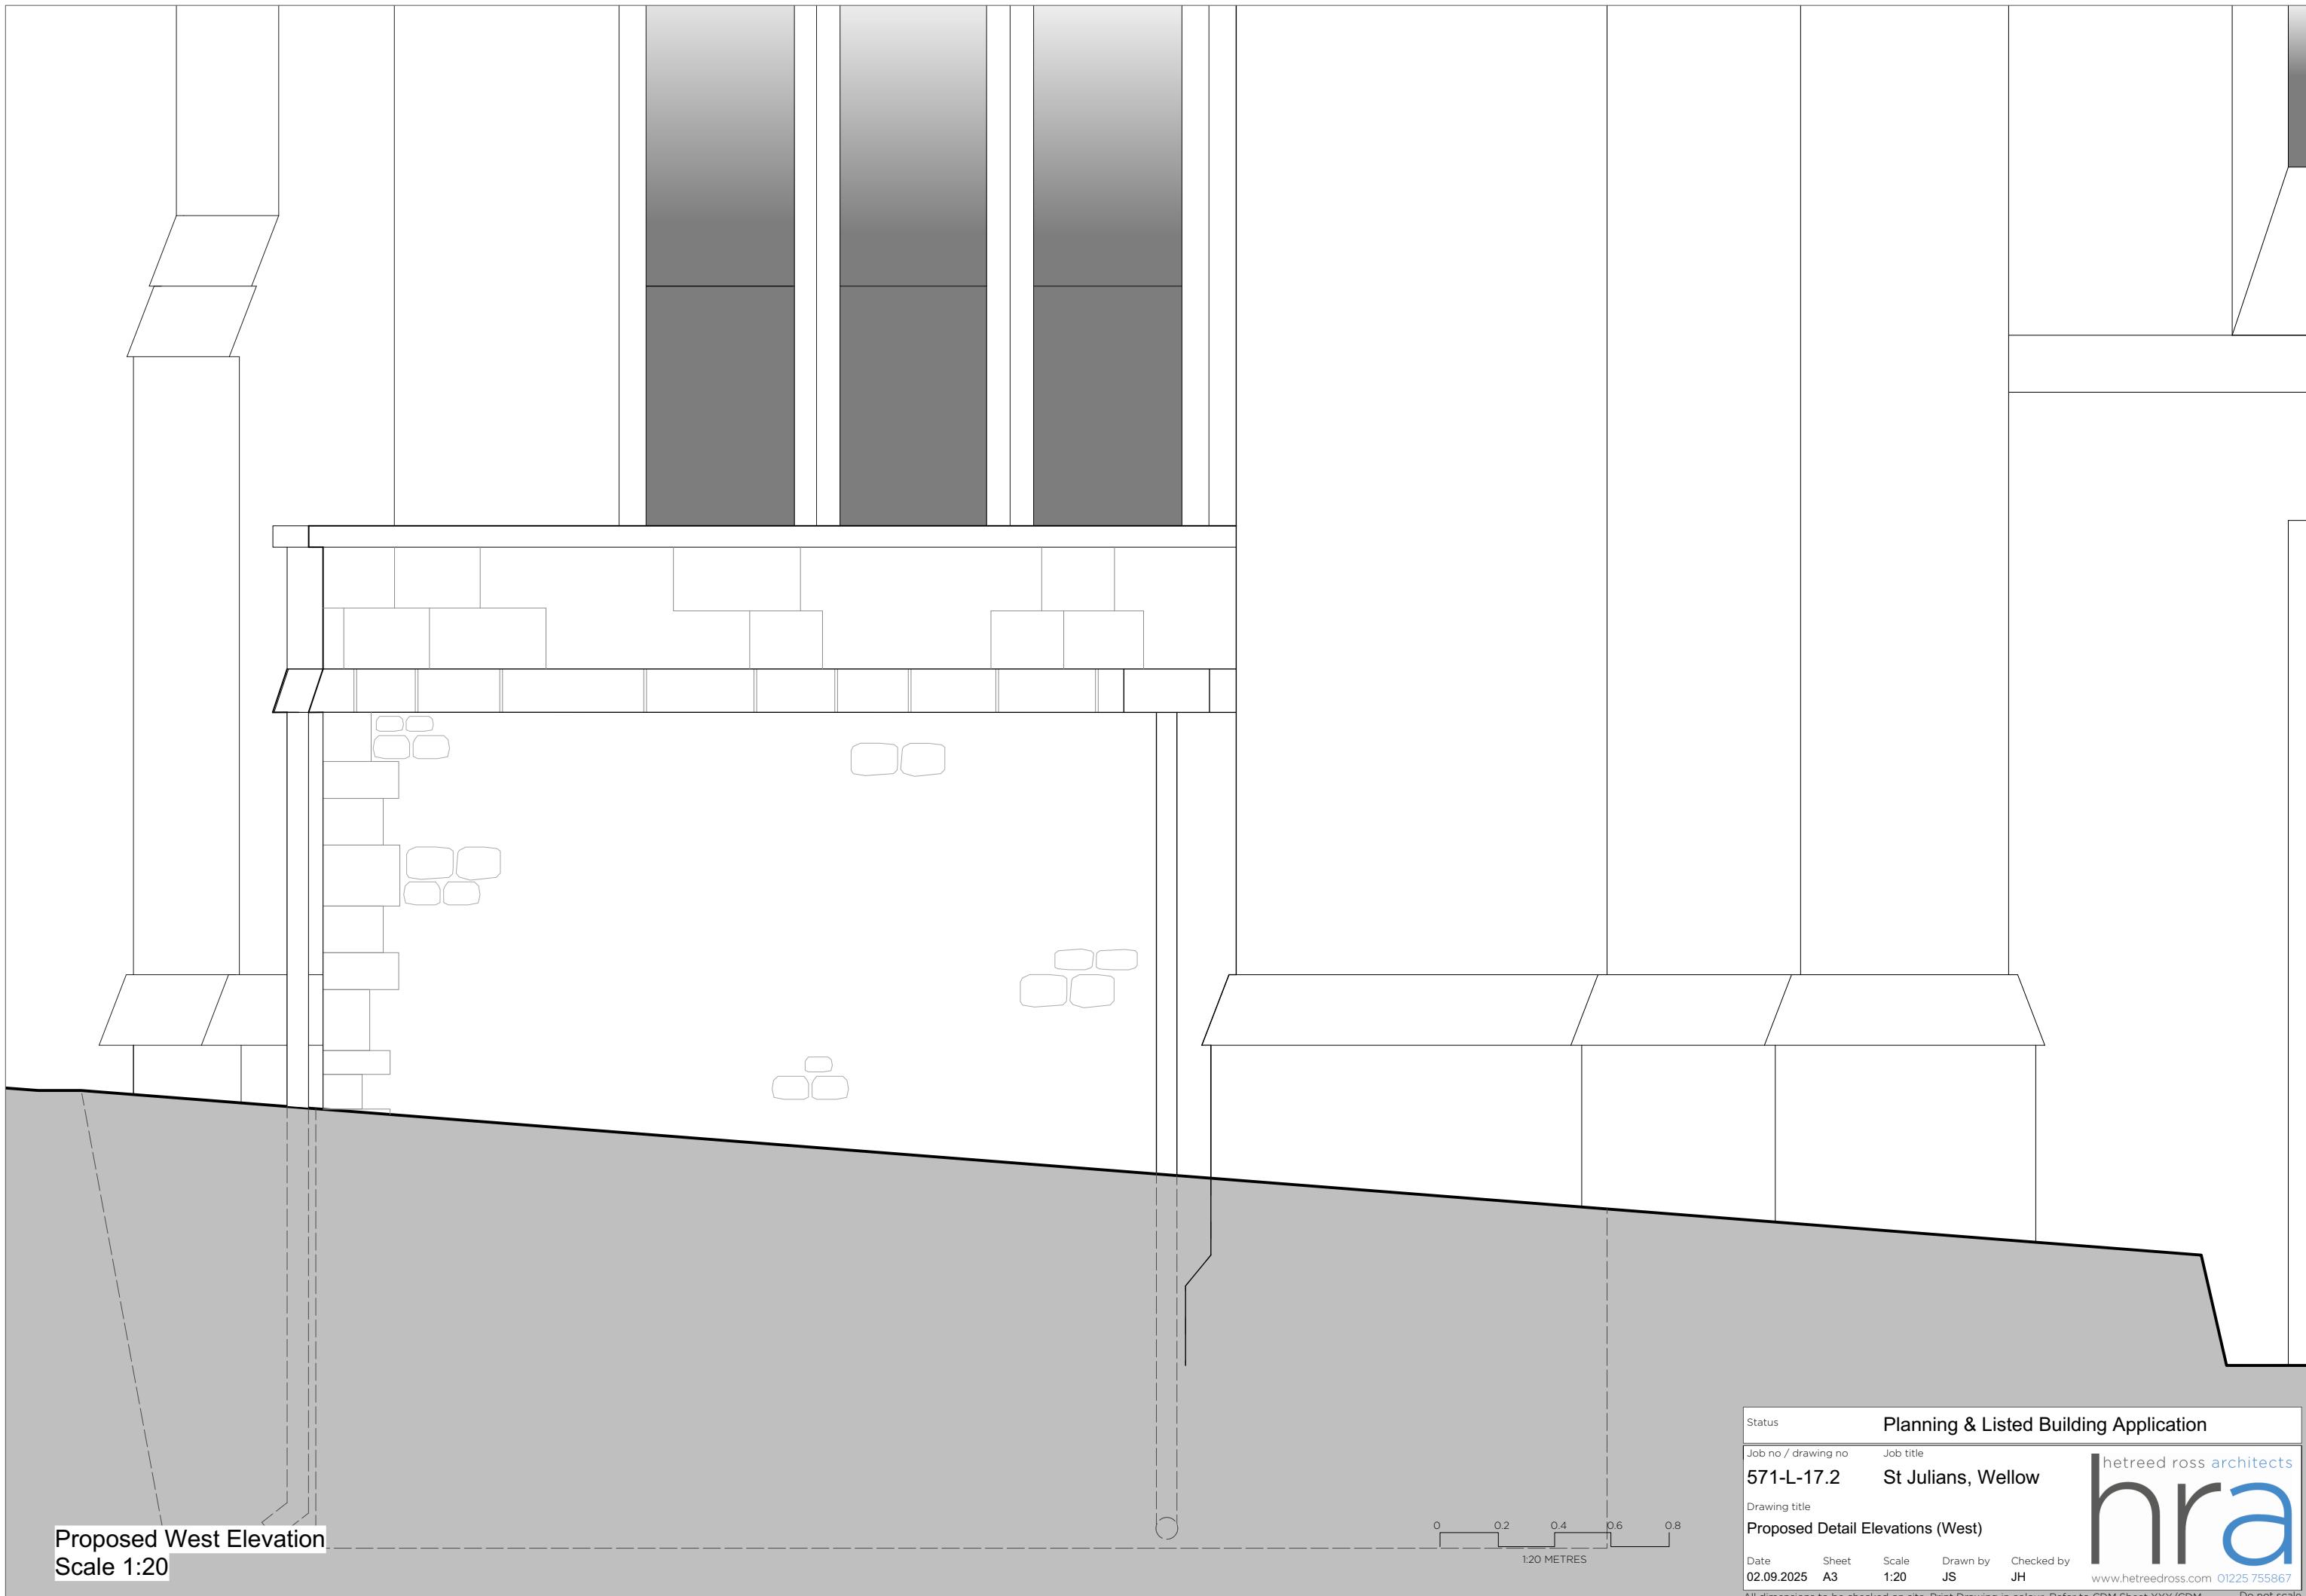

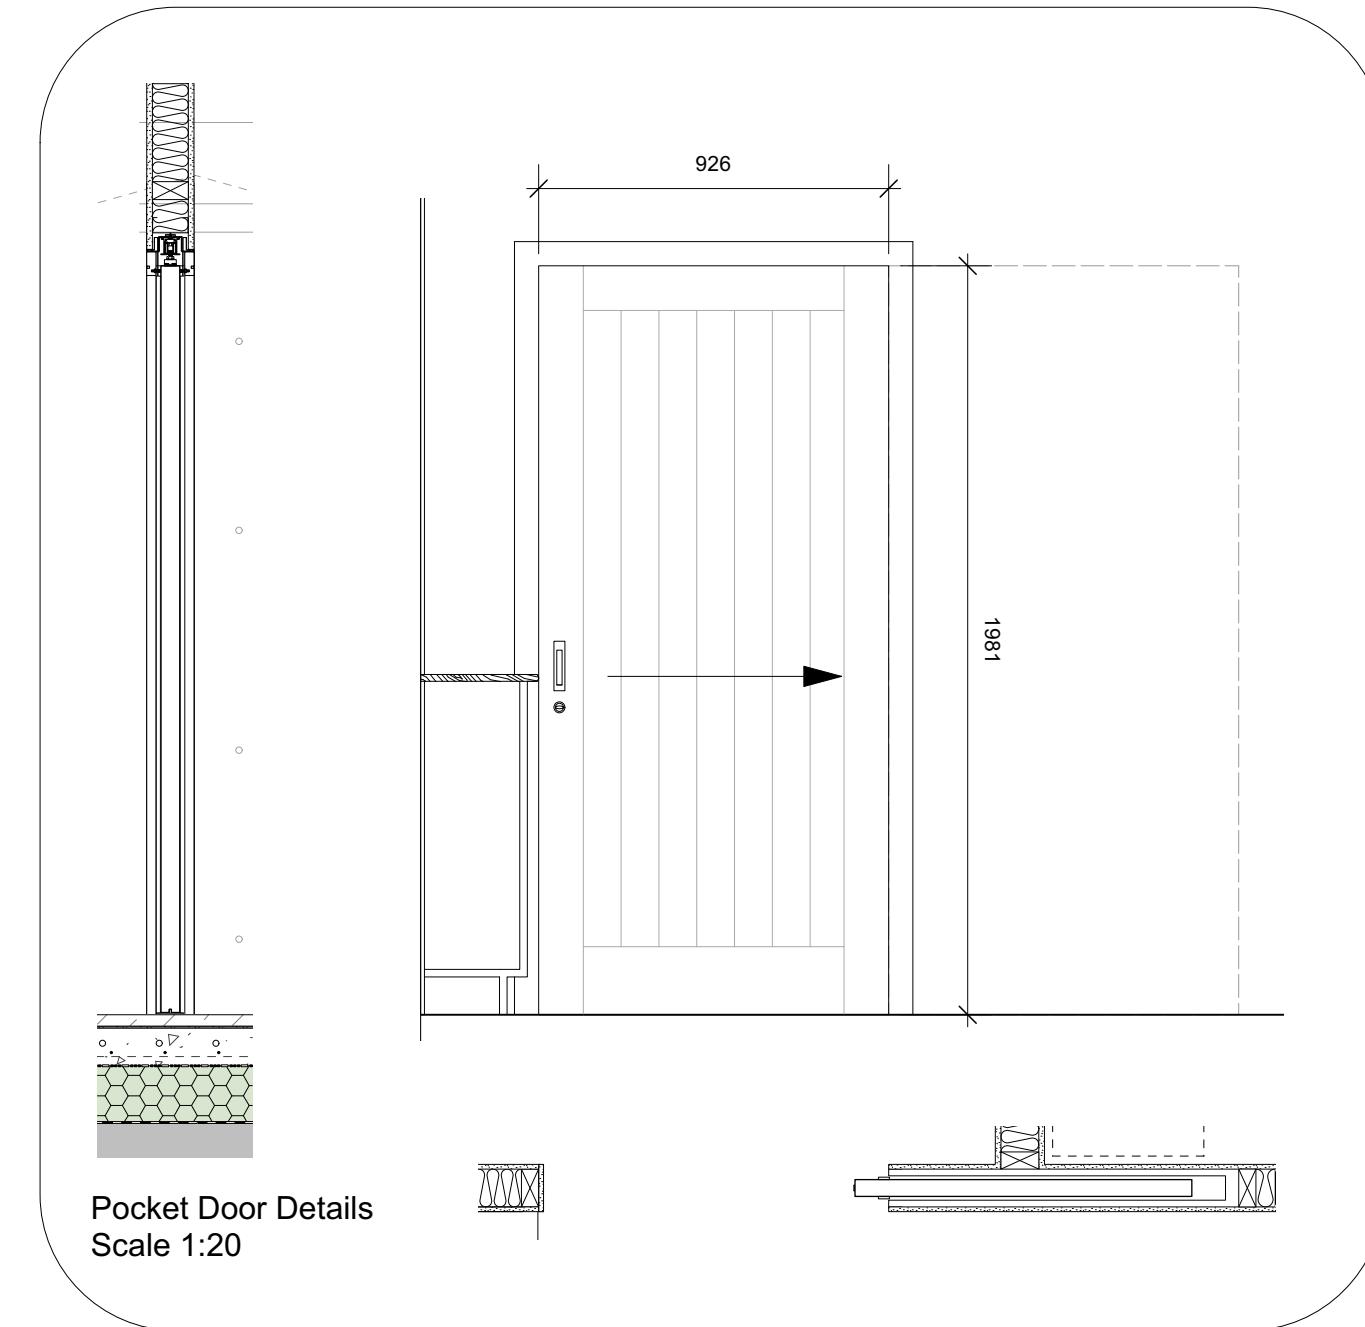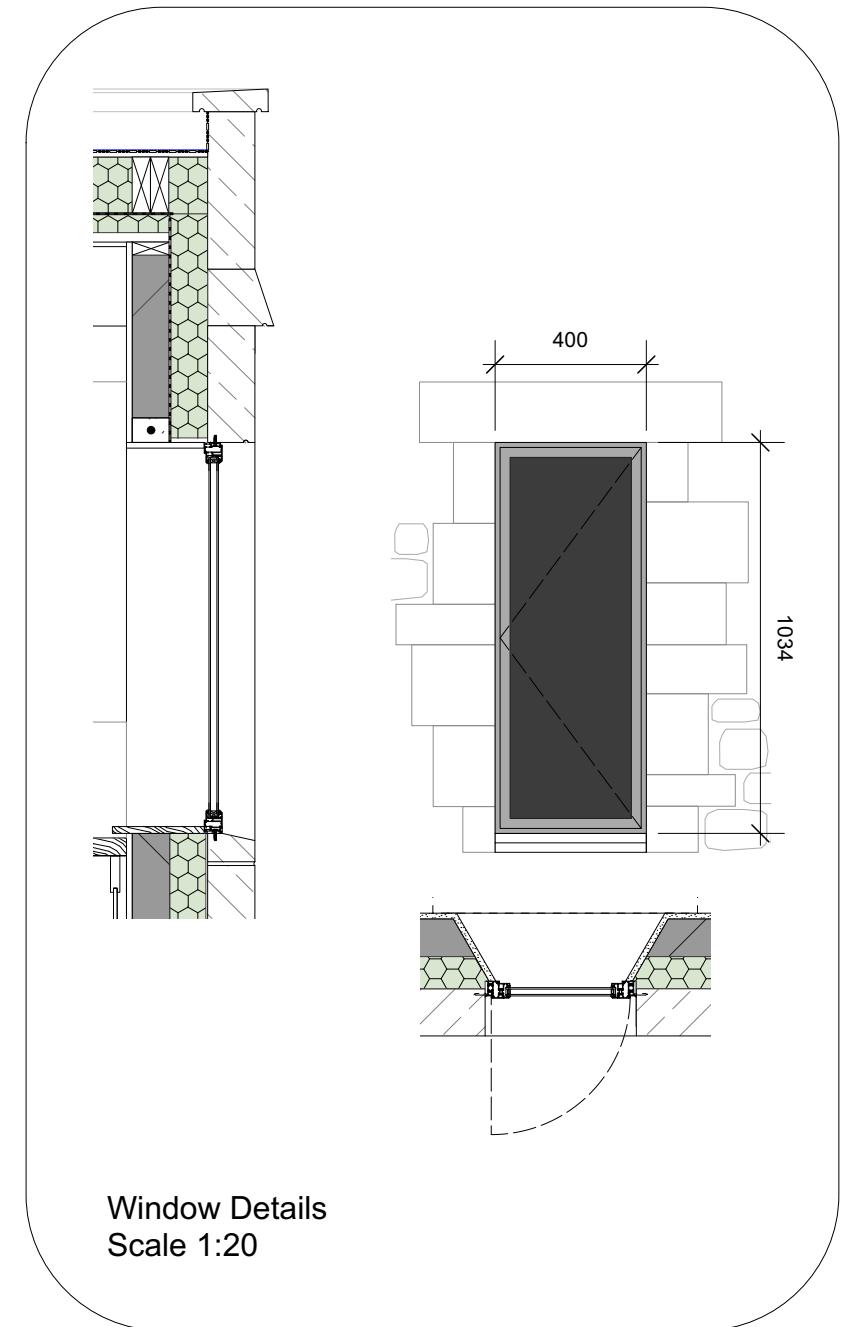


NOTE:
Planning approved rooflight omitted from works

0 0.2 0.4 0.6 0.8
1:20 METRES

Status	Planning & Listed Building Application				
Job no / drawing no	Job title				
571-L-18.1	St Julians, Wellow				
Drawing title					
Proposed Joinery Details					
Date	Sheet	Scale	Drawn by	Checked by	
02.09.2025	A3	1:20	JS	JH	
All dimensions to be checked on site. Print Drawing in colour. Refer to CDM Sheet XXX/CDM					

hetreed ross architects
hra
www.hetreedross.com 01225 755867
Do not scale

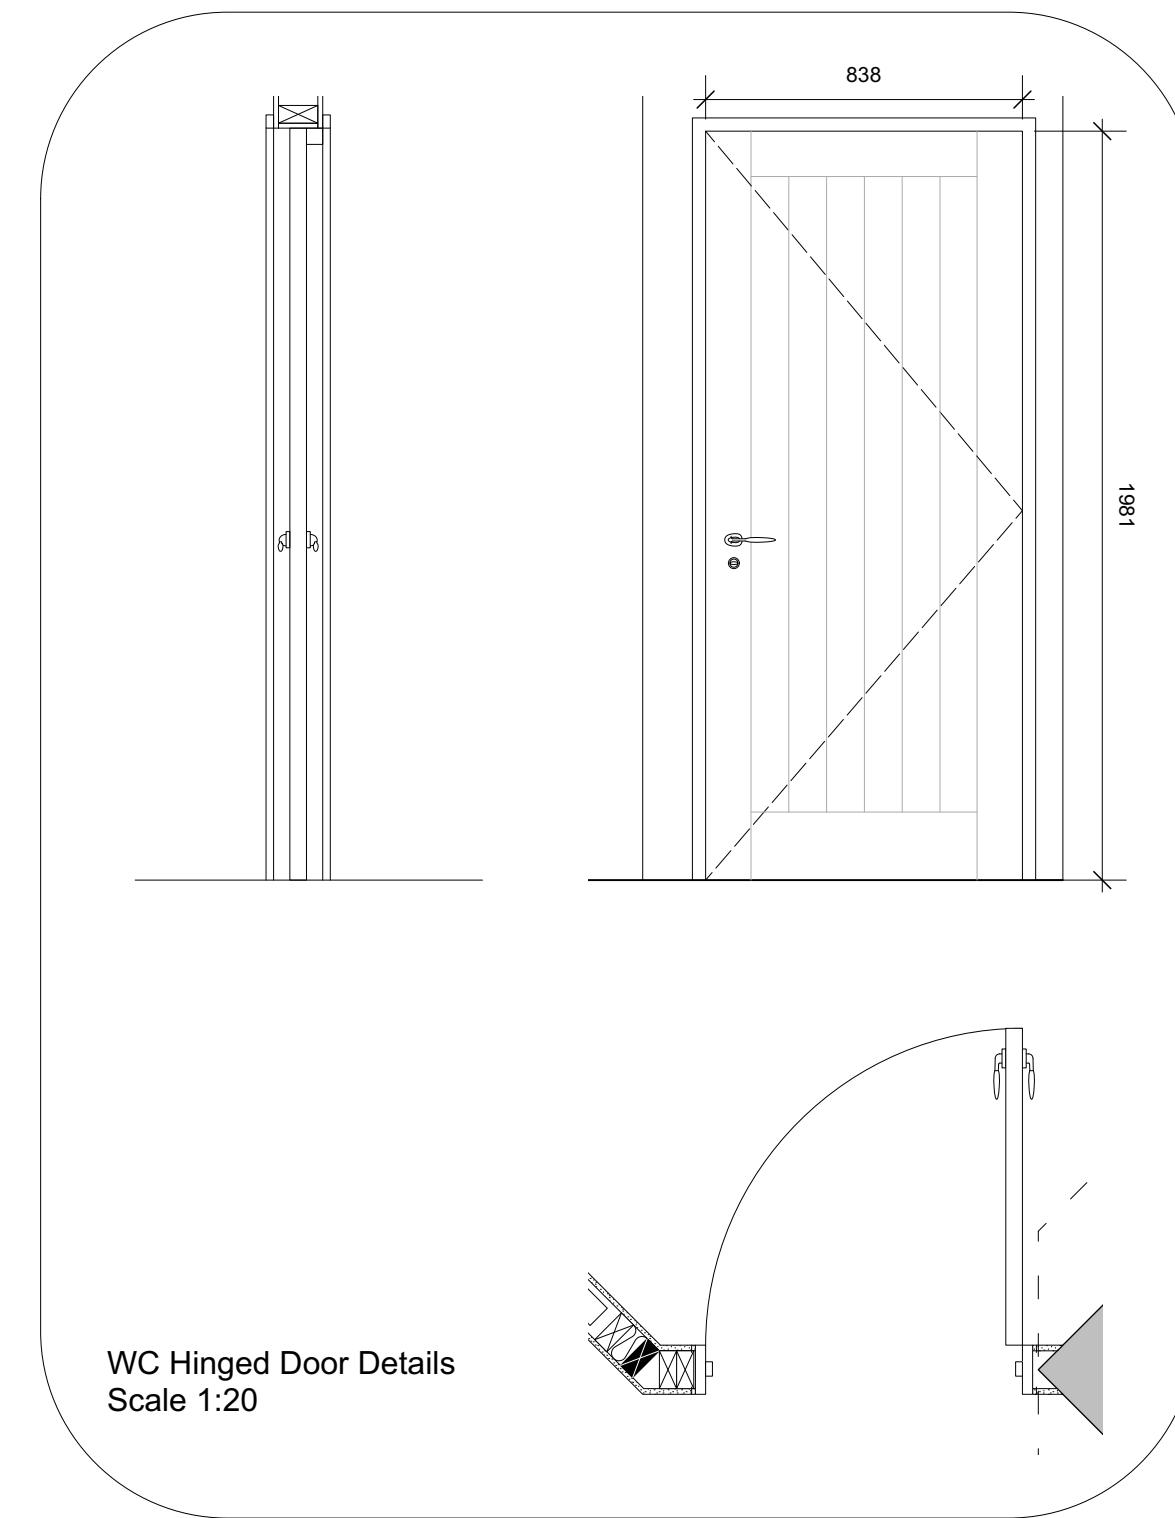

0 0.2 0.4 0.6 0.8
1:20 METRES

Status	Planning & Listed Building Application			
Job no / drawing no	Job title			
571-L-18.2	St Julians, Wellow			
Drawing title				
Proposed Joinery Details				
Date	Sheet	Scale	Drawn by	Checked by
02.09.2025	A3	1:20	JS	JH
All dimensions to be checked on site. Print Drawing in colour. Refer to CDM Sheet XXX/CDM				

hra hetreed ross architects
www.hetreedross.com 01225 755867