


Proposed North Elevation

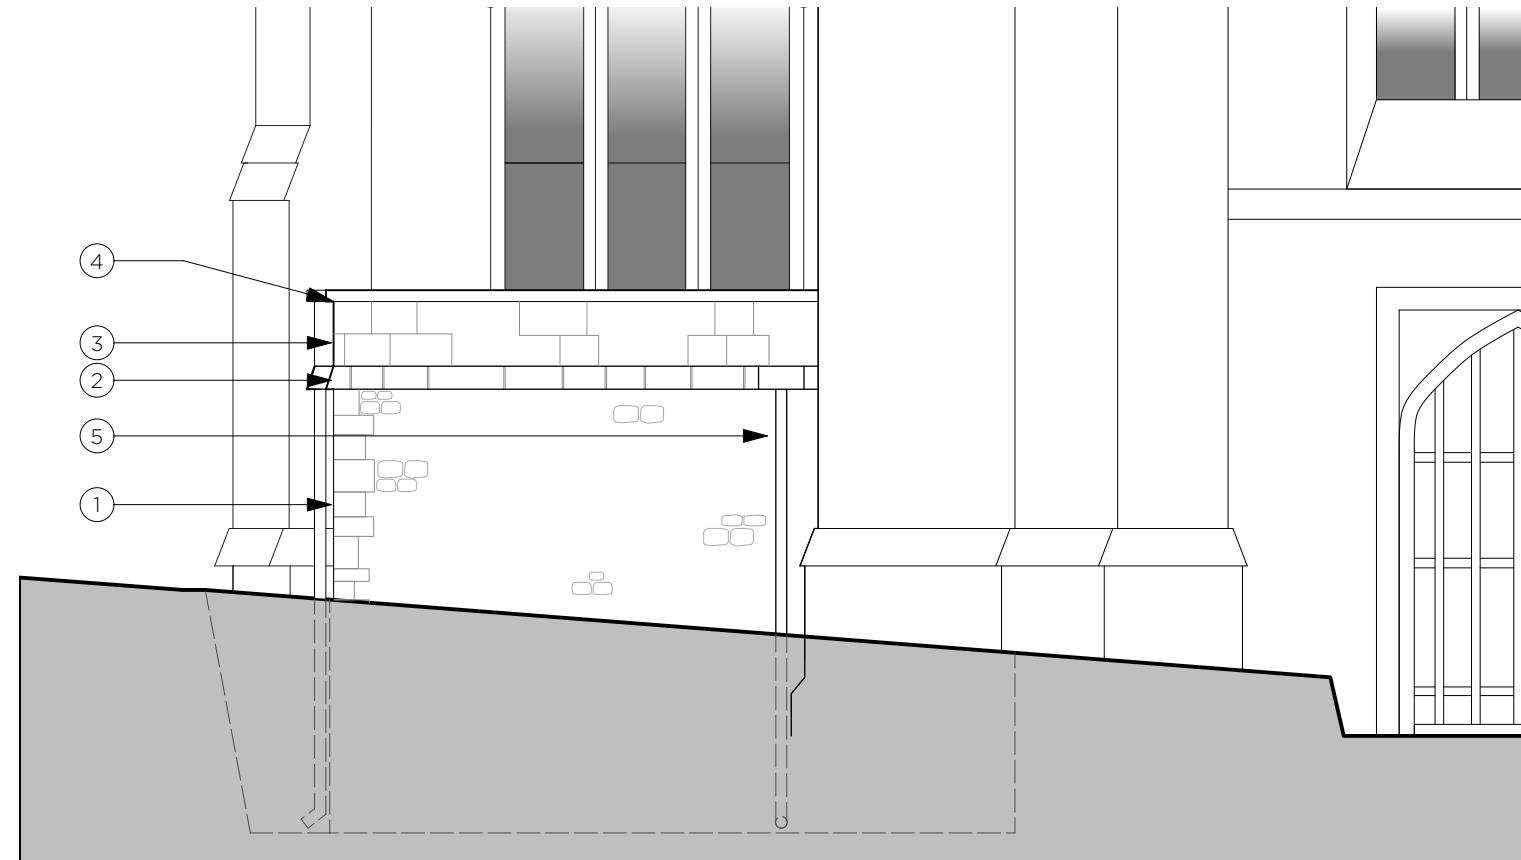

Proposed West Elevation

#### Key to Materials

1. Coursed rubble stone
2. Ashlar String course- to follow profile of existing string course
3. Ashlar Parapet
4. Ashlar coping, once weathered inwards
5. Terne Coated Stainless Steel rainwater goods
6. Grey PC thermally broken aluminium 'heritage' double glazed windows (frame detail tbc)

AMENDMENT:

DATE


Status	Faculty			
Job no / drawing no	Job title			
571-L-03	St Julians, Wellow			
Drawing title				
Proposed Elevations - Materiality				
Date	Sheet	Scale	Drawn by	Checked by
12-02-20	A3	1:100 1:50	MS	JH

0 0.5 1 1.5 2  
1:50 METRES

All dimensions to be checked on site. Print Drawing in colour. Refer to CDM Sheet XXX/CDM


www.hetreedross.com 01225 755867

Do not scale

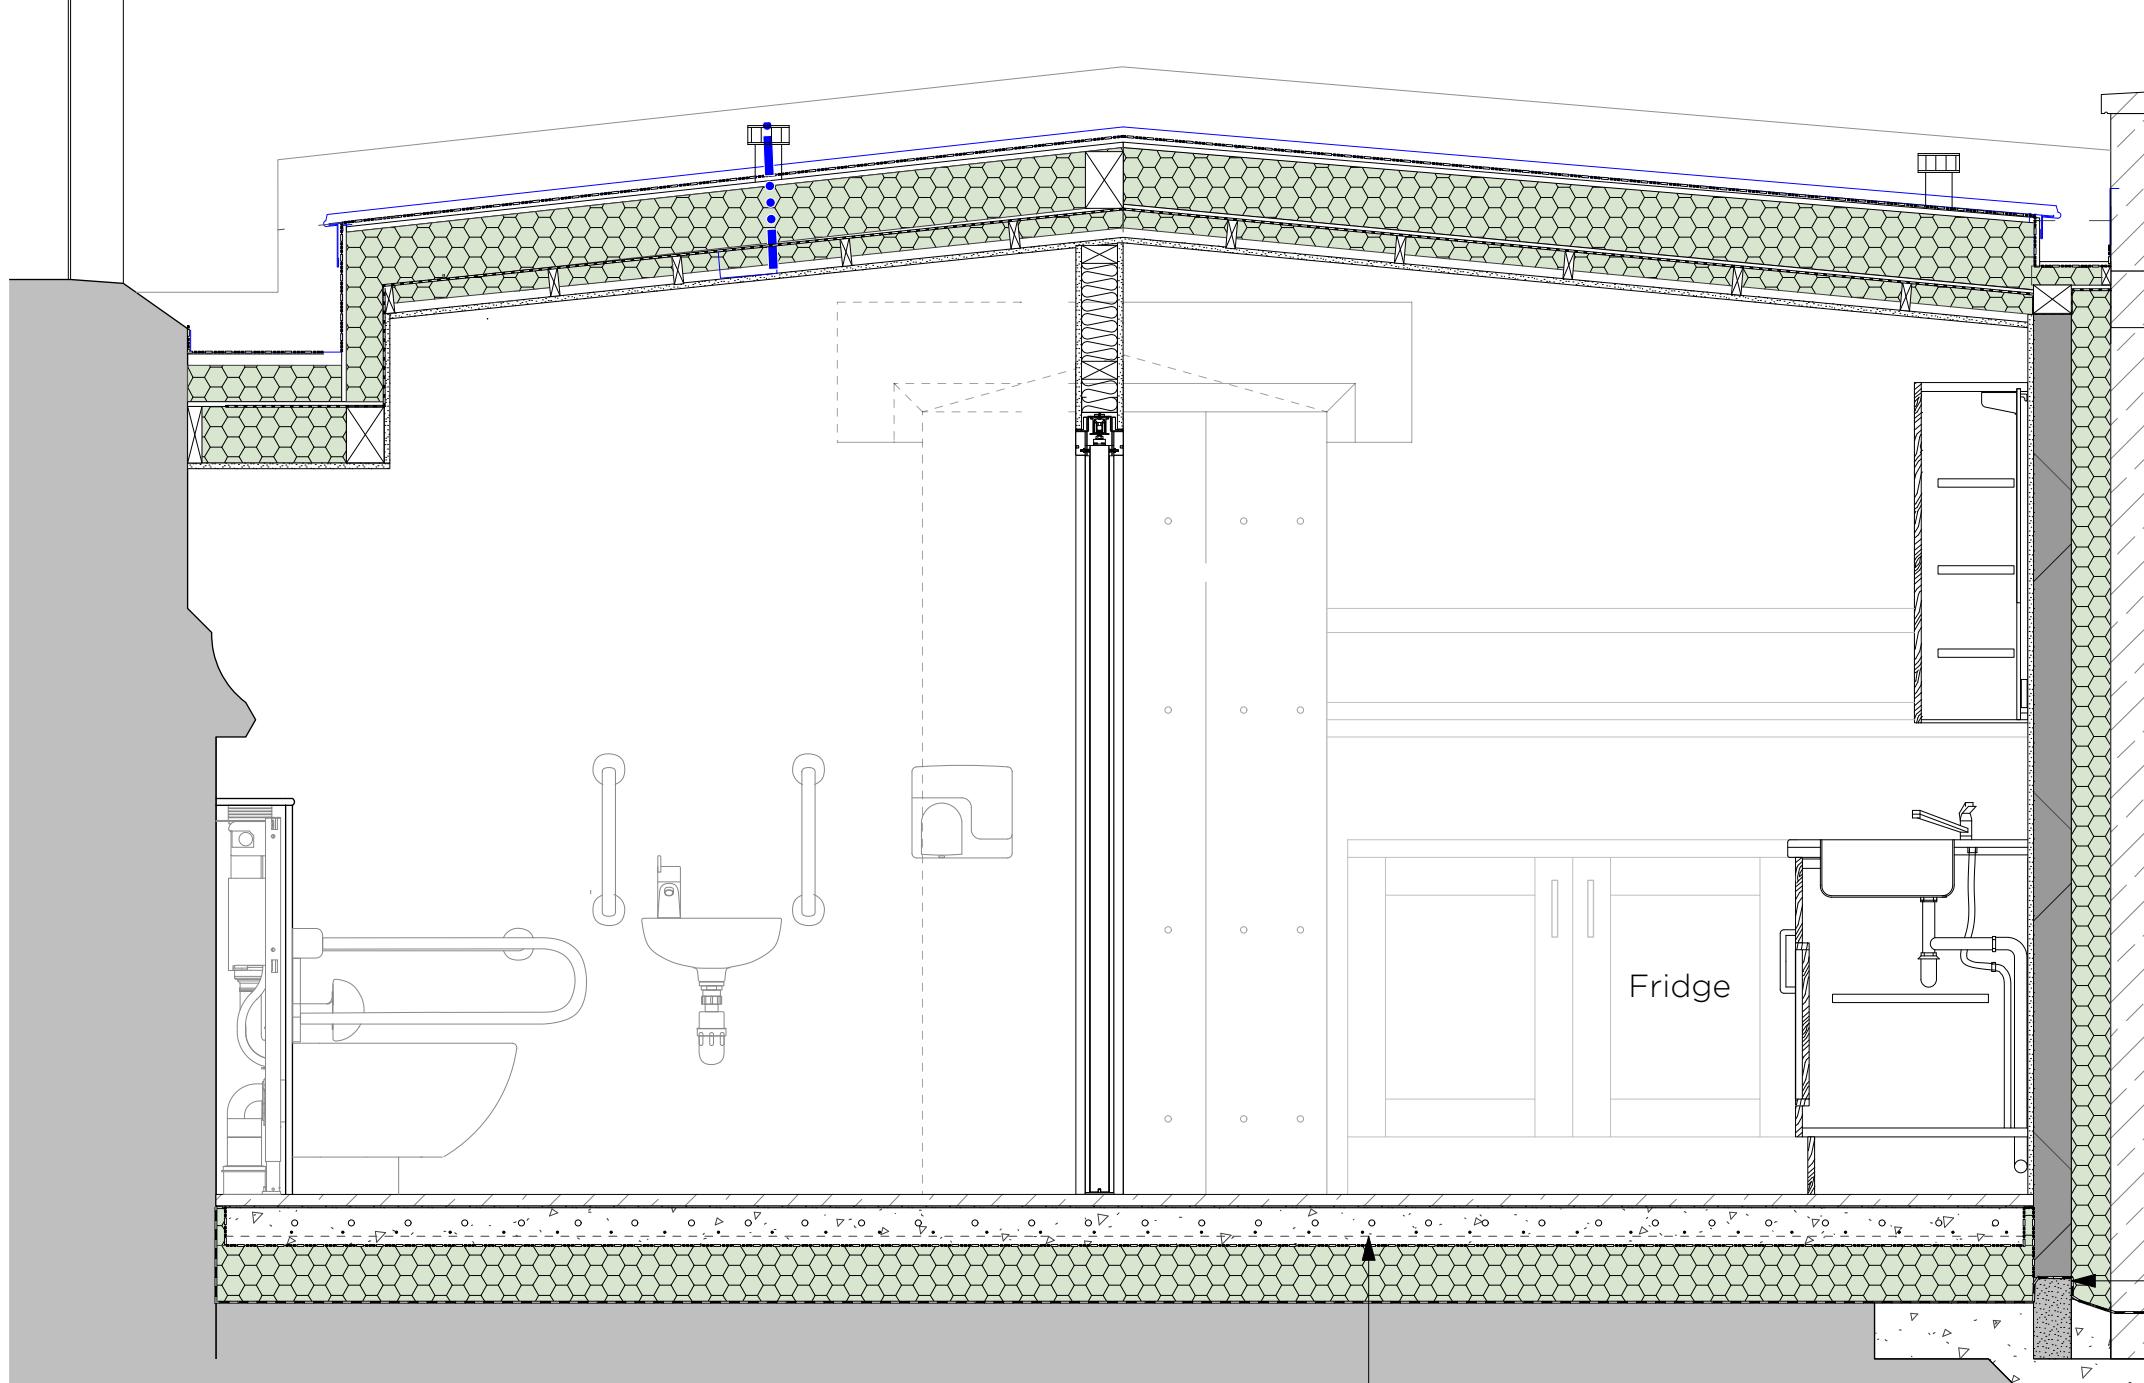

Section AA 1:20

Underfloor heating  
within slab on A142 mesh

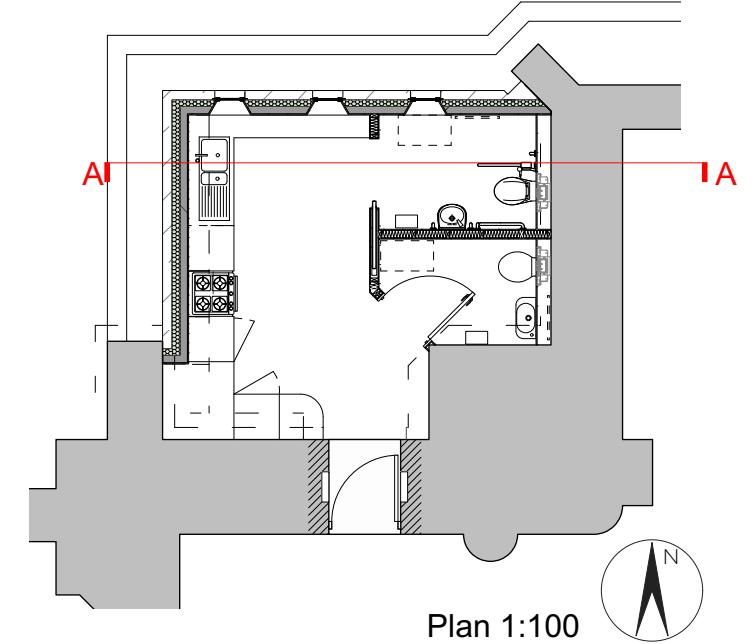

Plan 1:100


2nd course  
Celcon Solar  
Weeps

Footing to  
structural eng.  
specification

AMENDMENT:


DATE

Status	Faculty
Job no / drawing no	Job title
<b>571-L-04</b>	
Drawing title	
<b>Proposed Section AA</b>	
Date	Sheet
12-02-20	A3
Scale	Drawn by
1:100	MS
Checked by	JH
All dimensions to be checked on site. Print Drawing in colour. Refer to CDM Sheet XXX/CDM	
www.hetreedross.com 01225 755867	
Do not scale	

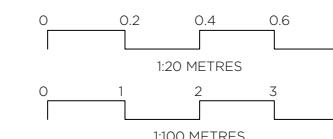

hetreed ross architects  
**hra**  
www.hetreedross.com 01225 755867

In situ RC lintel  
to S.E details

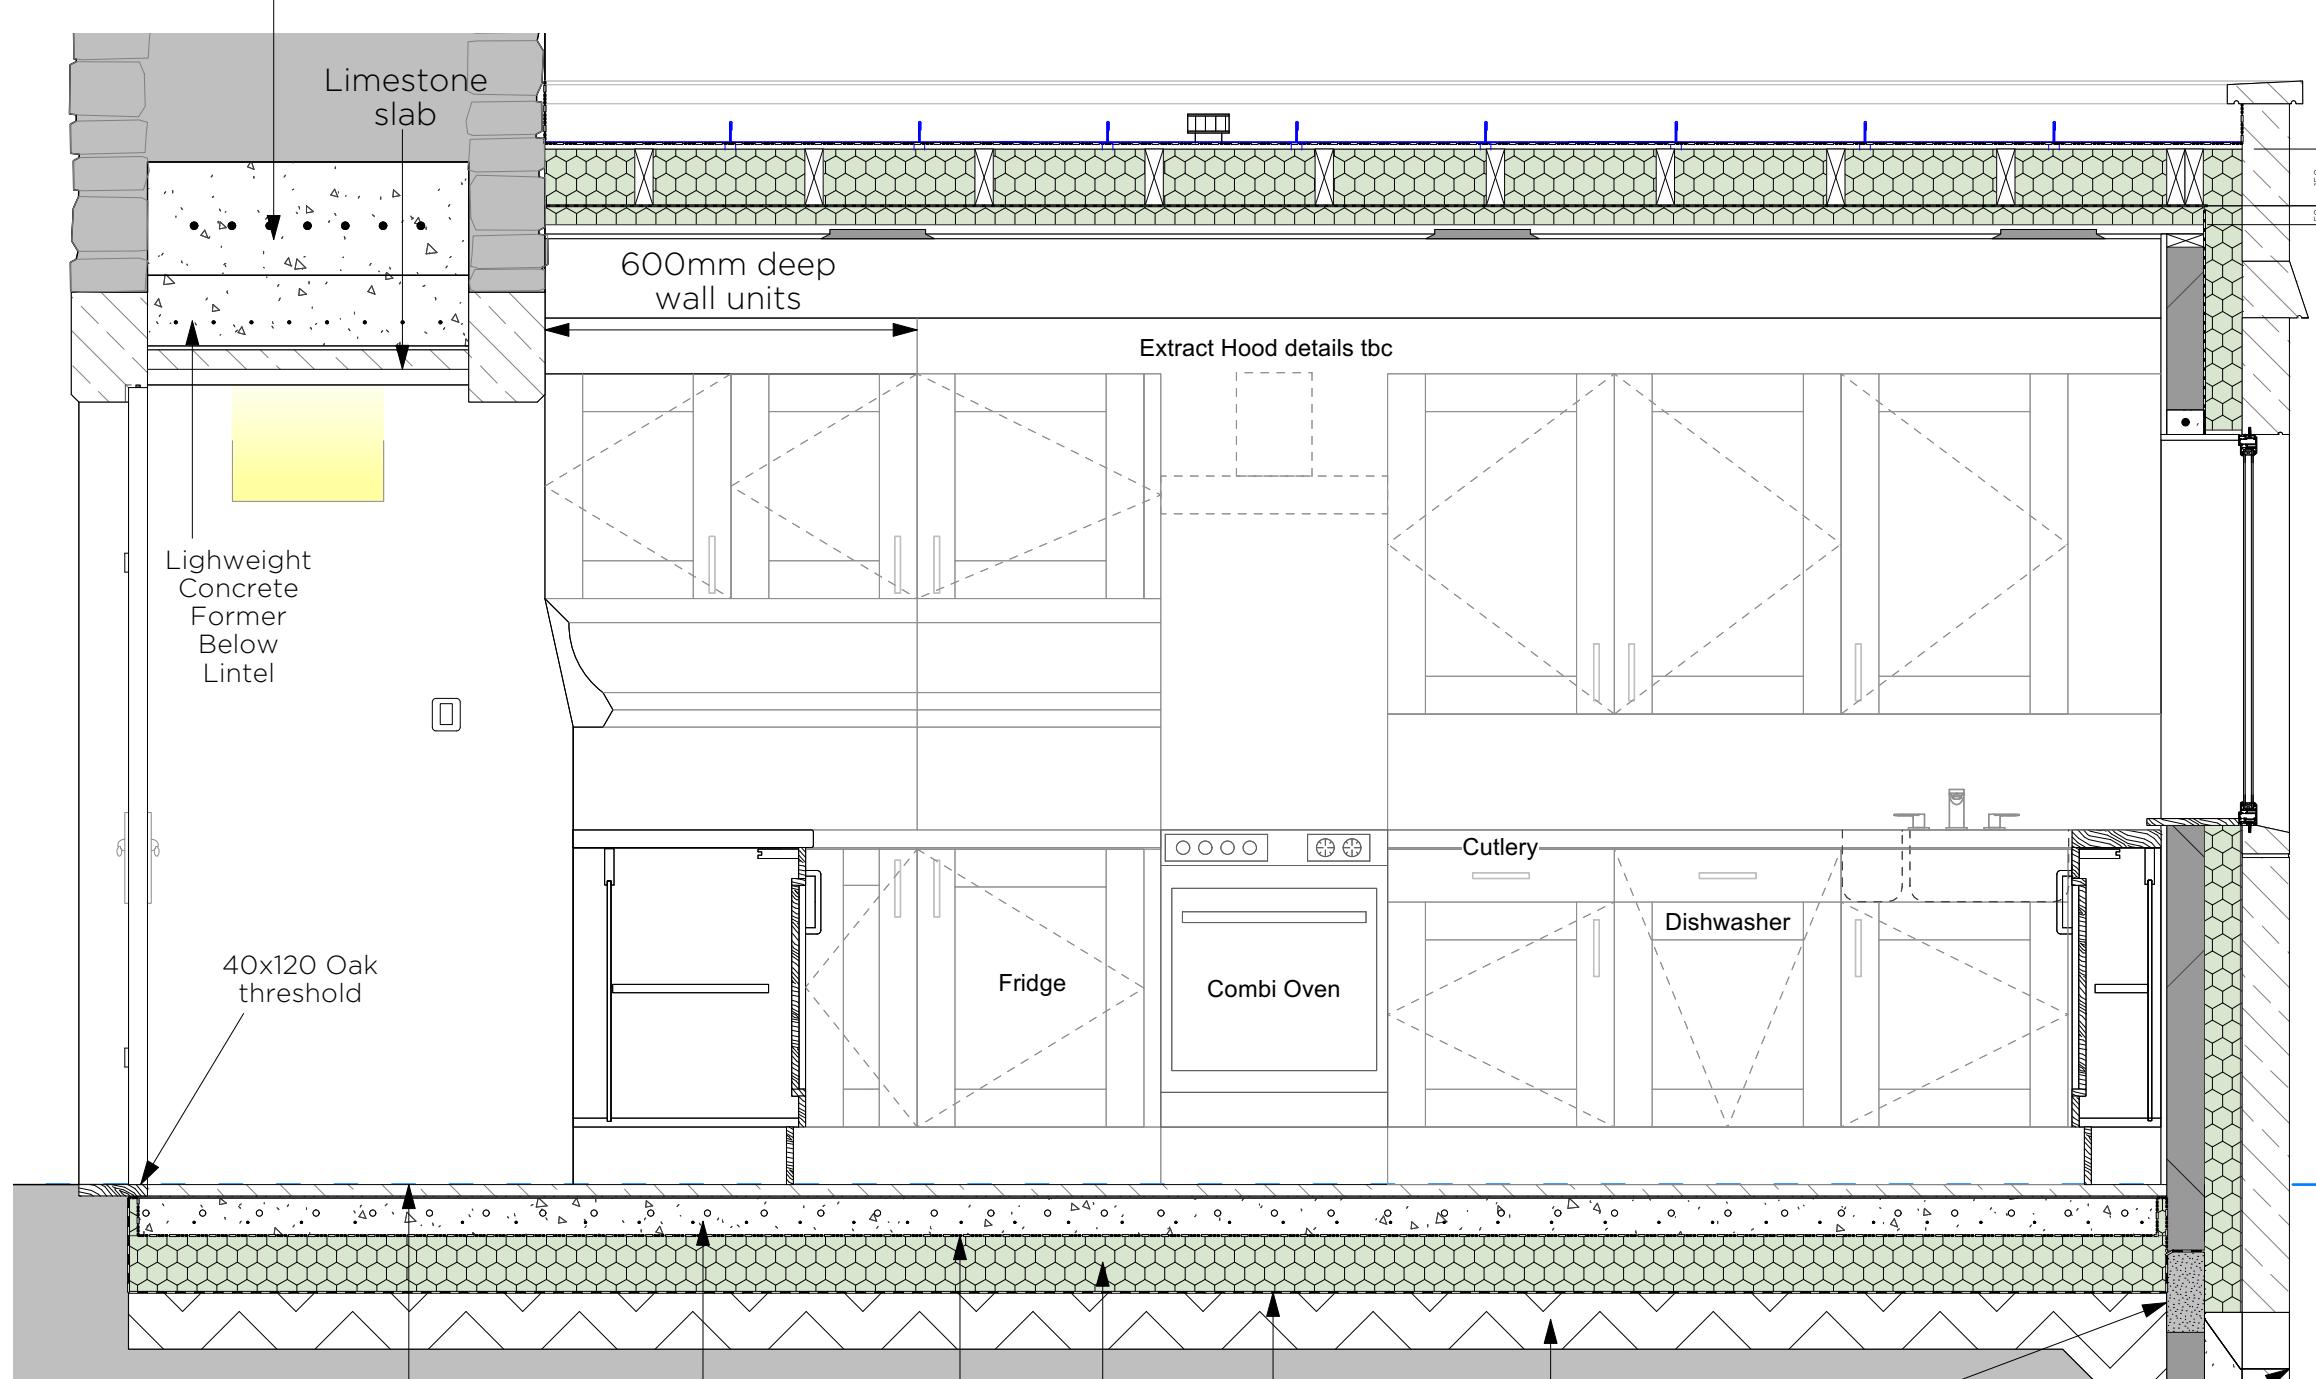

Section BB 1:20

100mm screeded  
slab with underfloor  
heating pipes on  
A142 mesh

VCL 250


150mm  
PIR

Min. 50mm  
gravel/sand  
blinding  
(tbc after excavation)


Celcon  
solar to  
line with  
floor  
insulation

Weeps to  
perps at  
450  
centres

IB

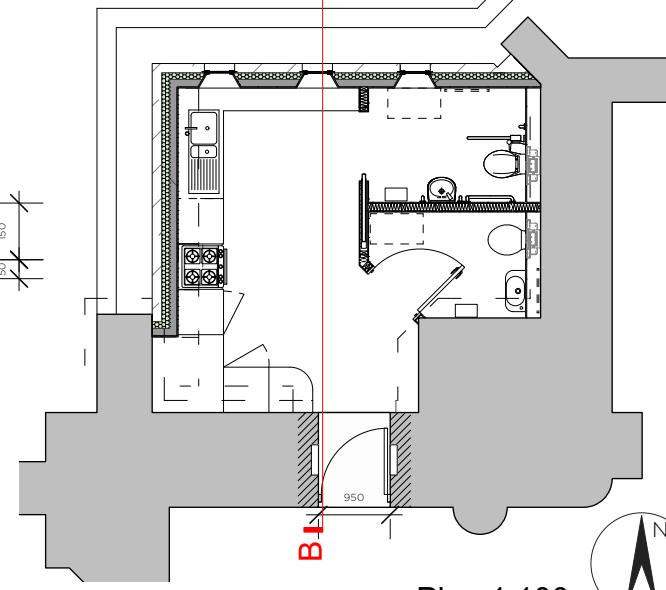

Insulated water main and  
electric sub-main from  
vestry

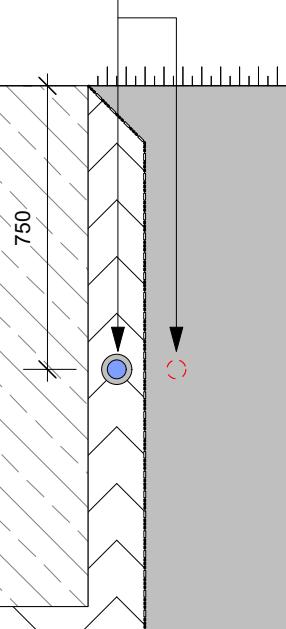


AMENDMENT:


DATE

Status	Faculty			
Job no / drawing no	Job title			
571-L-05	St Julians, Wellow			
Drawing title				
Proposed Section BB				
Date	Sheet	Scale	Drawn by	Checked by
12-02-20	A3	1:100 1:20	MS	JH


hetreed ross architects  
**hra**  
www.hetreedross.com 01225 755867  
Do not scale

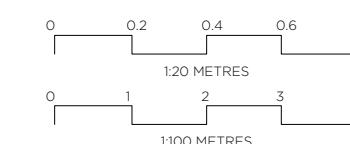


All dimensions to be checked on site. Print Drawing in colour. Refer to CDM Sheet XXX/CDM

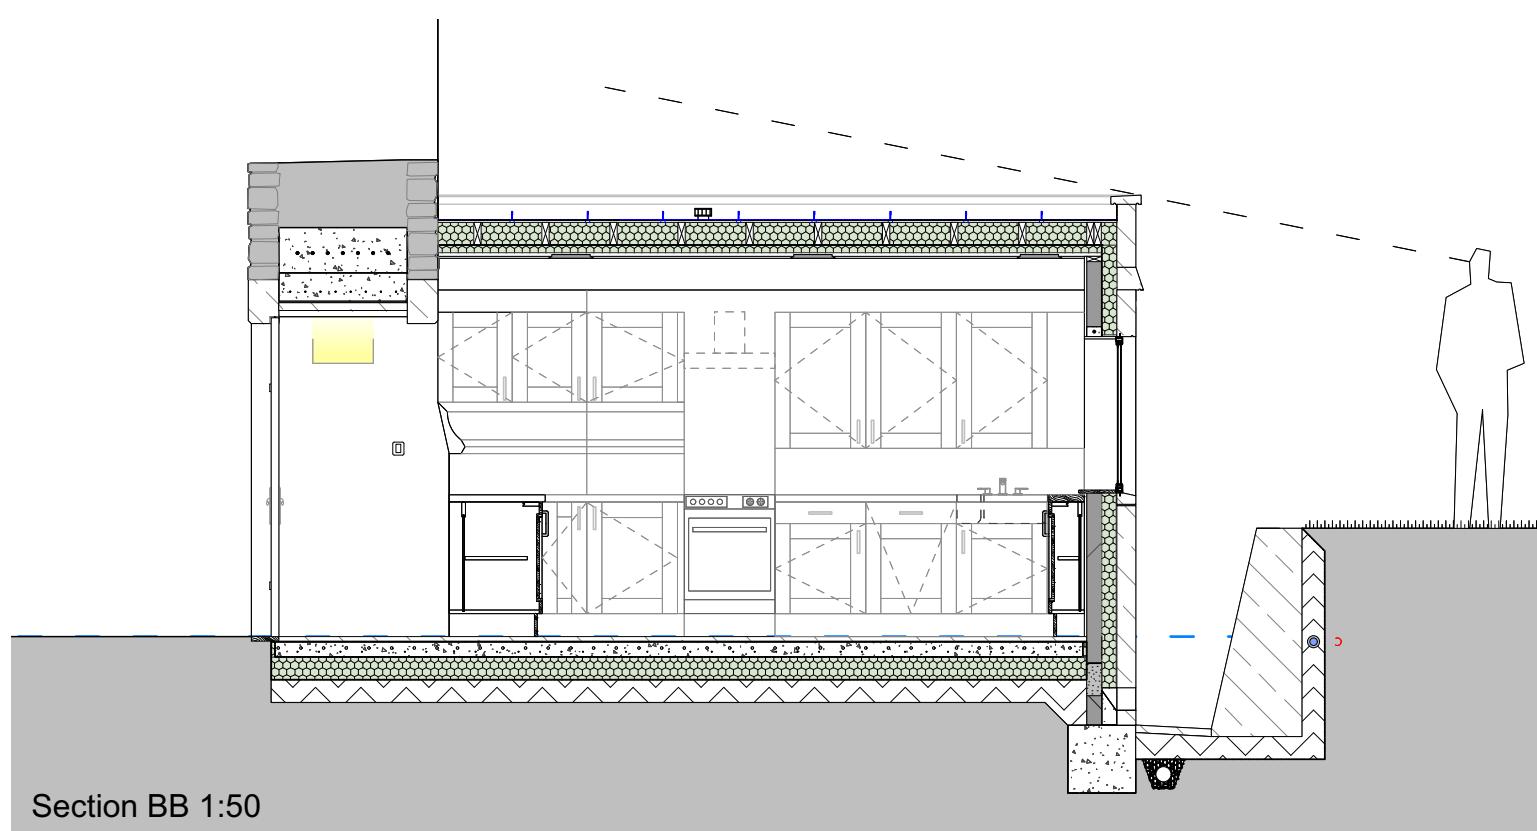

Section BB 1:50

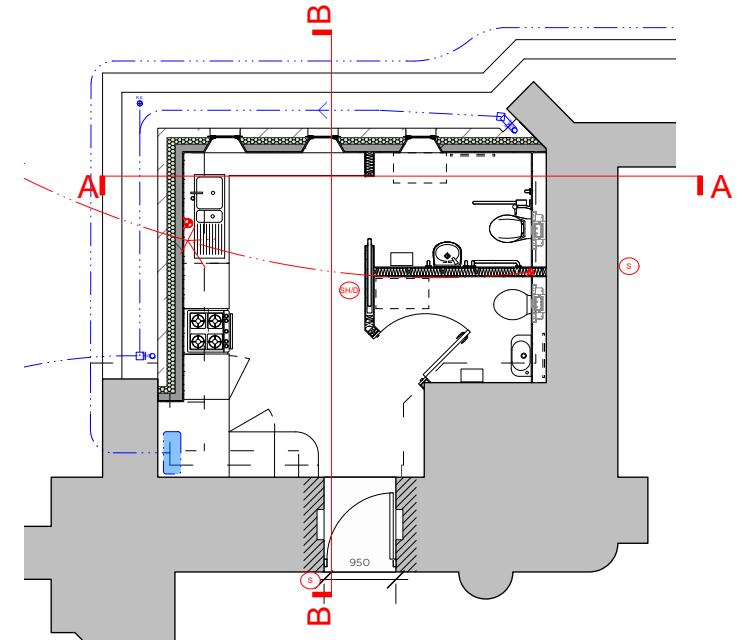

Plan 1:100

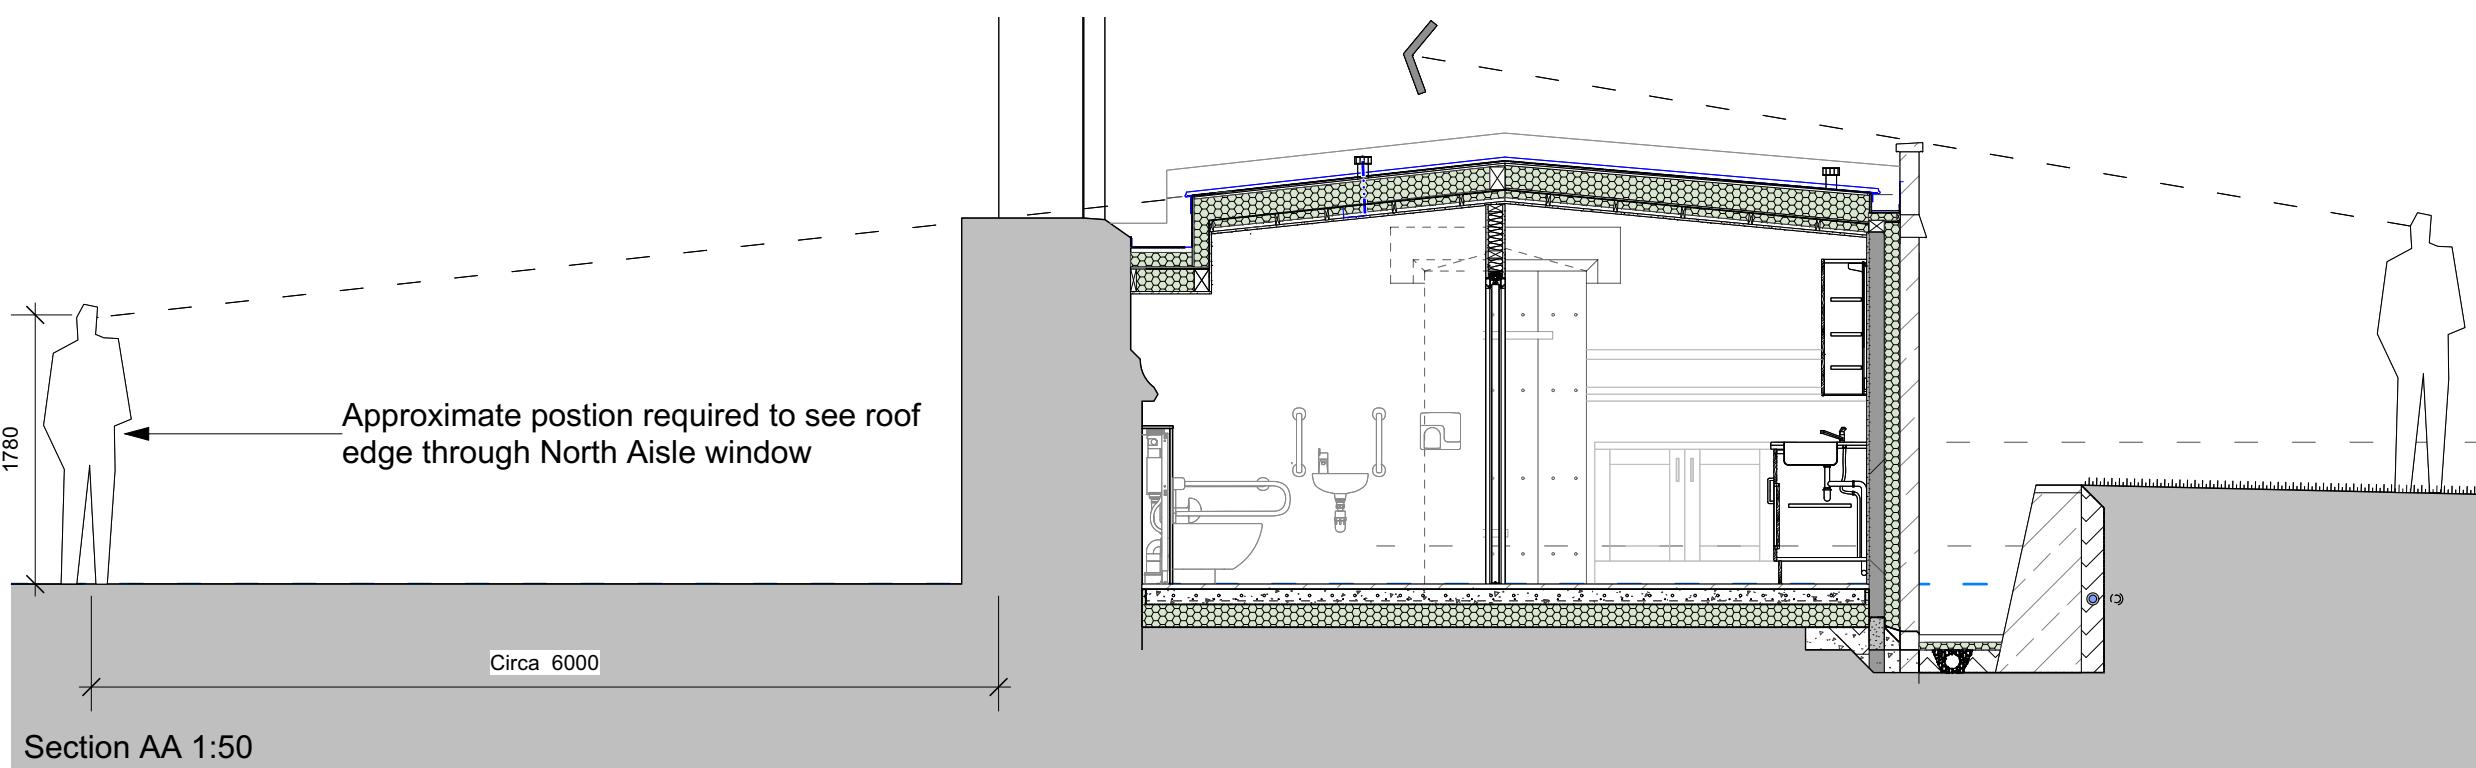


Section AA 1:50

AMENDMENT:		DATE		
Faculty				
Status	Job no / drawing no	Job title		
	571-L-06			
Drawing title				
Proposed Sections				
Date	Sheet	Scale	Drawn by	Checked by
12-02-20	A3	1:100 1:50	MS	JH
All dimensions to be checked on site. Print Drawing in colour. Refer to CDM Sheet XXX/CDM				

0 0.5 1 1.5 2  
1:50 METRES

0 1 2 3 4  
1:100 METRES

hetreed ross architects  
**hra**  
www.hetreedross.com 01225 755867

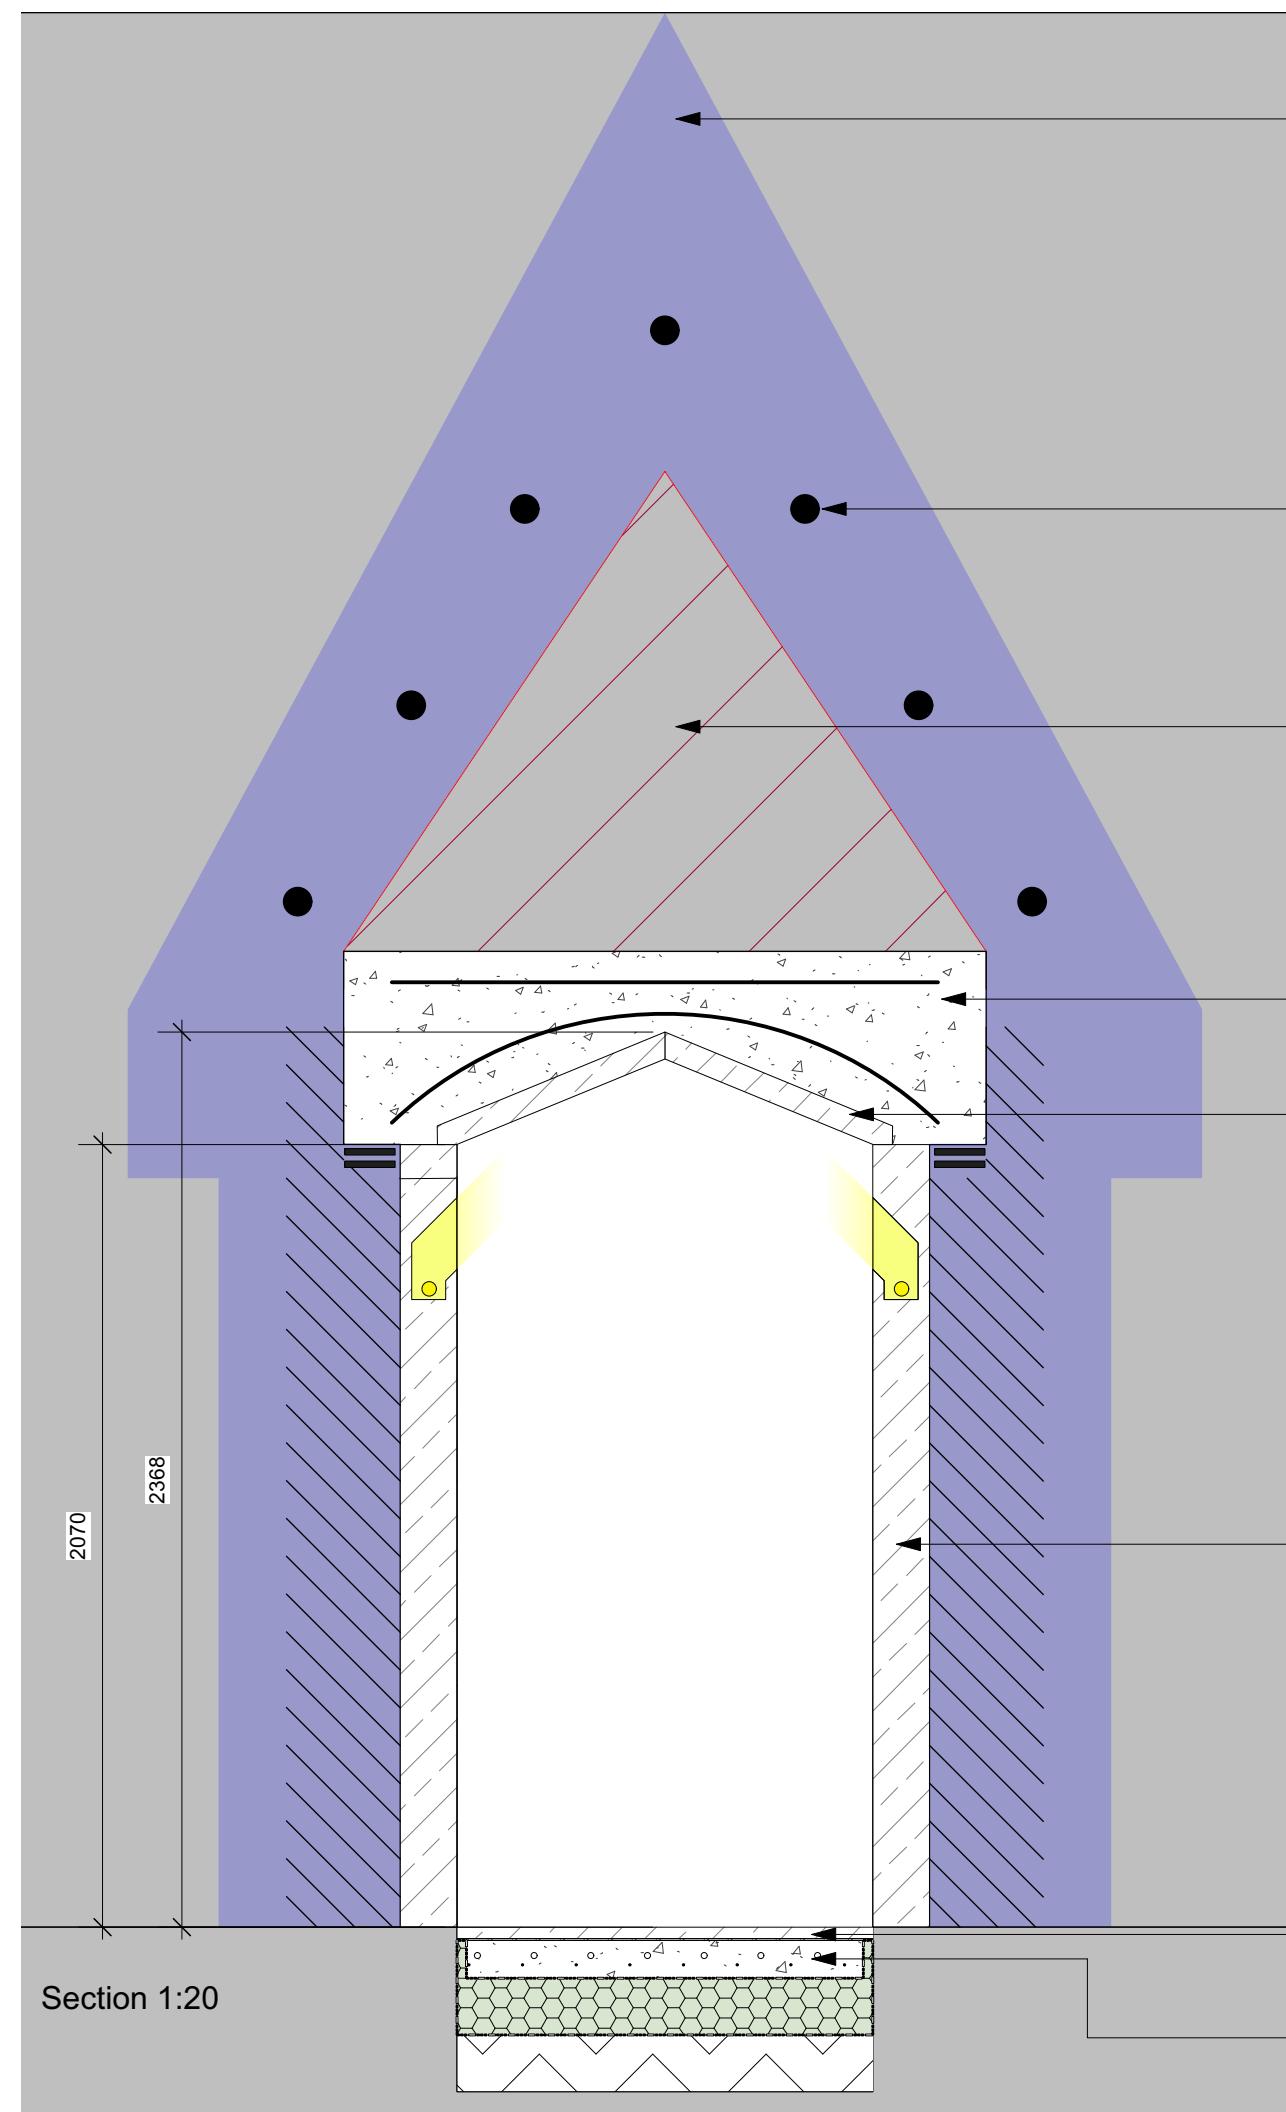

Elevation 1:50

Build in (permanent) galv. steel needles (to eng. spec)- cut back to inside face of facework, galvafroid and make good

CAREFULLY dismantle area above proposed door to form new cast in situ reinforced concrete slab. Make good above concrete reinstating rubble fill and grout

New Reinforced concrete arch lintel to engineers specification



Angled lime stone soffit through doorway (Purbeck Thornback tbc)

Flat Ashlar lintel with chamfer (as South door in tower) at 2360mm from G.L to suit existing coursing

Facing stone from door way used as cheeks for doorway with new to match - joint reinforcing to eng. spec

Extend limestone paving into door forming level threshold

Underfloor heating within slab

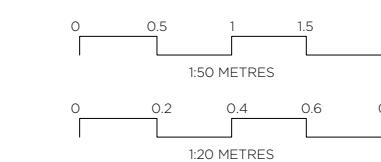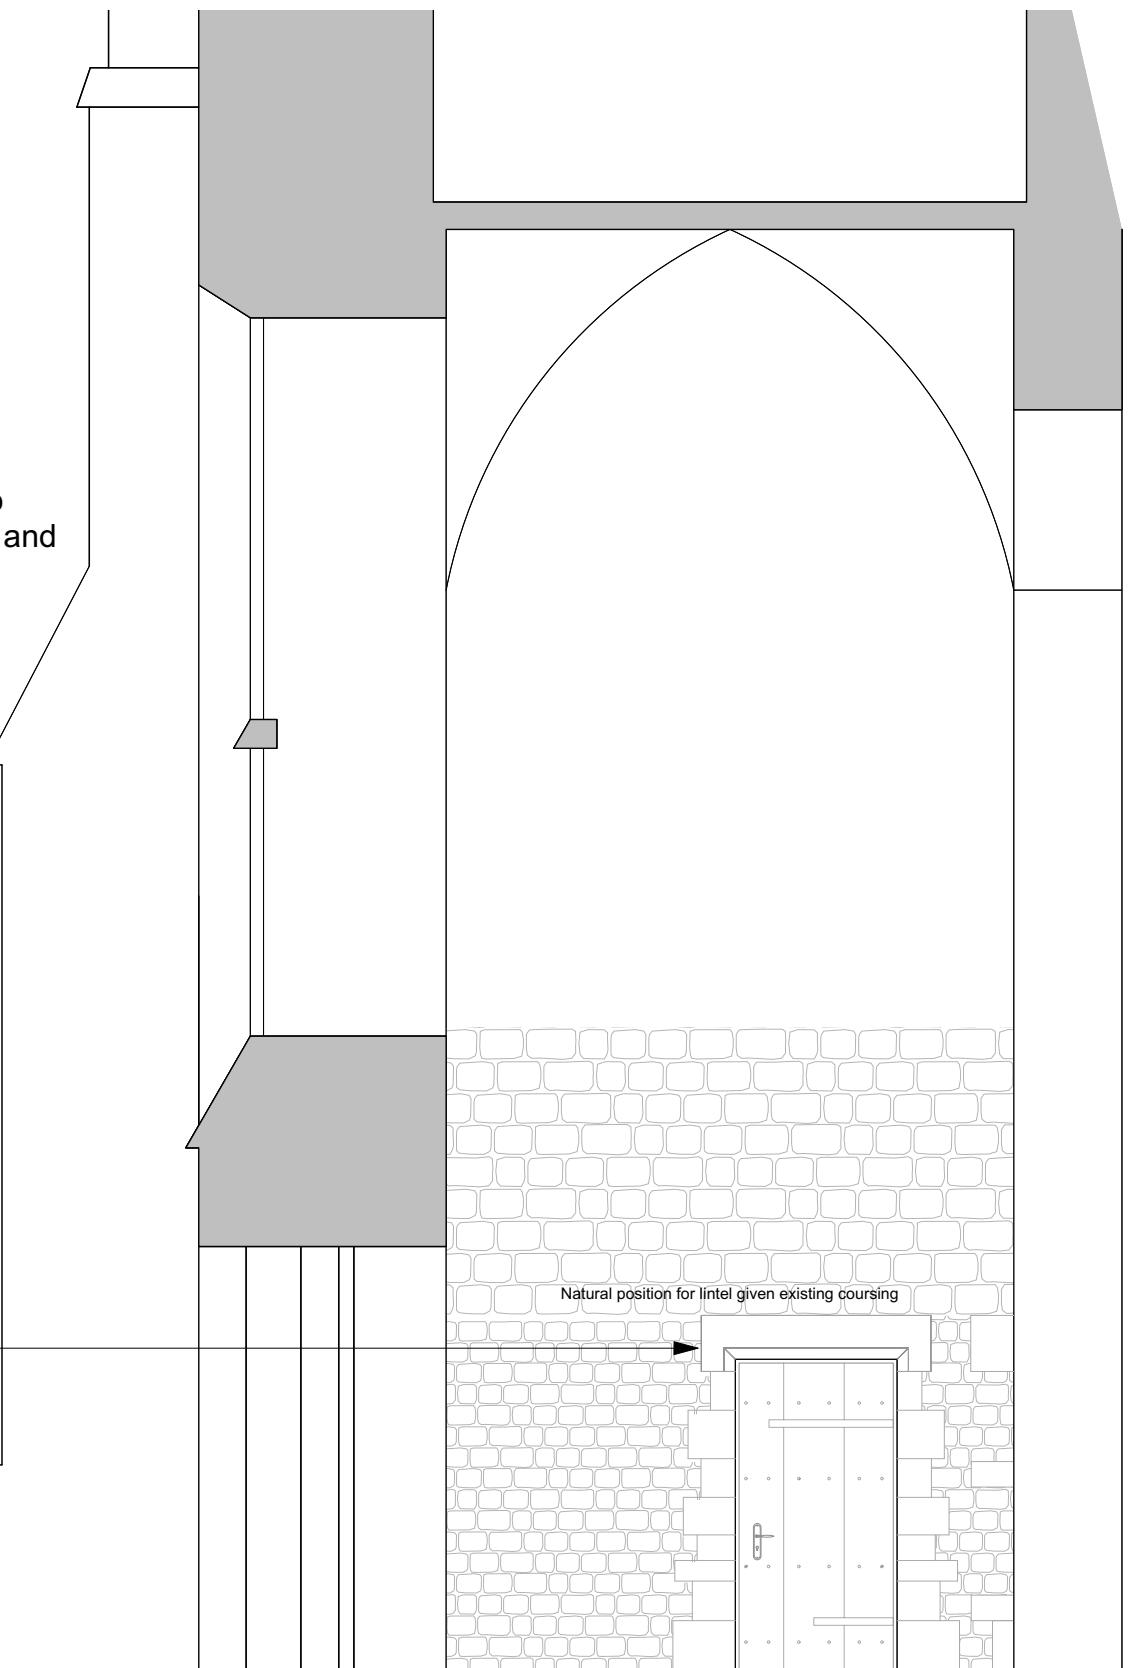

AMENDMENT:  
B. Revisions following PCC meeting  
A: Door pitch enlarged, lintel position defined

DATE  
26.02.25  
04.02.25

Status		Faculty
Job no / drawing no	Job title	
571-L-07	St Julians, Wellow	hetreed ross architects
	Drawing title	Proposed Doorway
Date 12-02-20	Sheet A3	Scale 1:100
		Drawn by MS
		Checked by JH
All dimensions to be checked on site. Print Drawing in colour. Refer to CDM Sheet XXX/CDM		
www.hetreedross.com 01225 755867		
Do not scale		



Existing West Elevation



Proposed West Elevation



Status	Faculty		
Job no / drawing no	Job title		
<b>571-L-08</b>	<b>St Julians, Wellow</b>		
Drawing title			
West Elevation - Existing and Proposed			
Date	Sheet	Scale	Drawn by
18-03-20	A3	1:100	HH
Checked by JH			

0 1 2 3 4  
1:100 METRES

All dimensions to be checked on site. Print Drawing in colour. Refer to CDM Sheet XXX/CDM

www.hetreedross.com 01225 755867

Do not scale

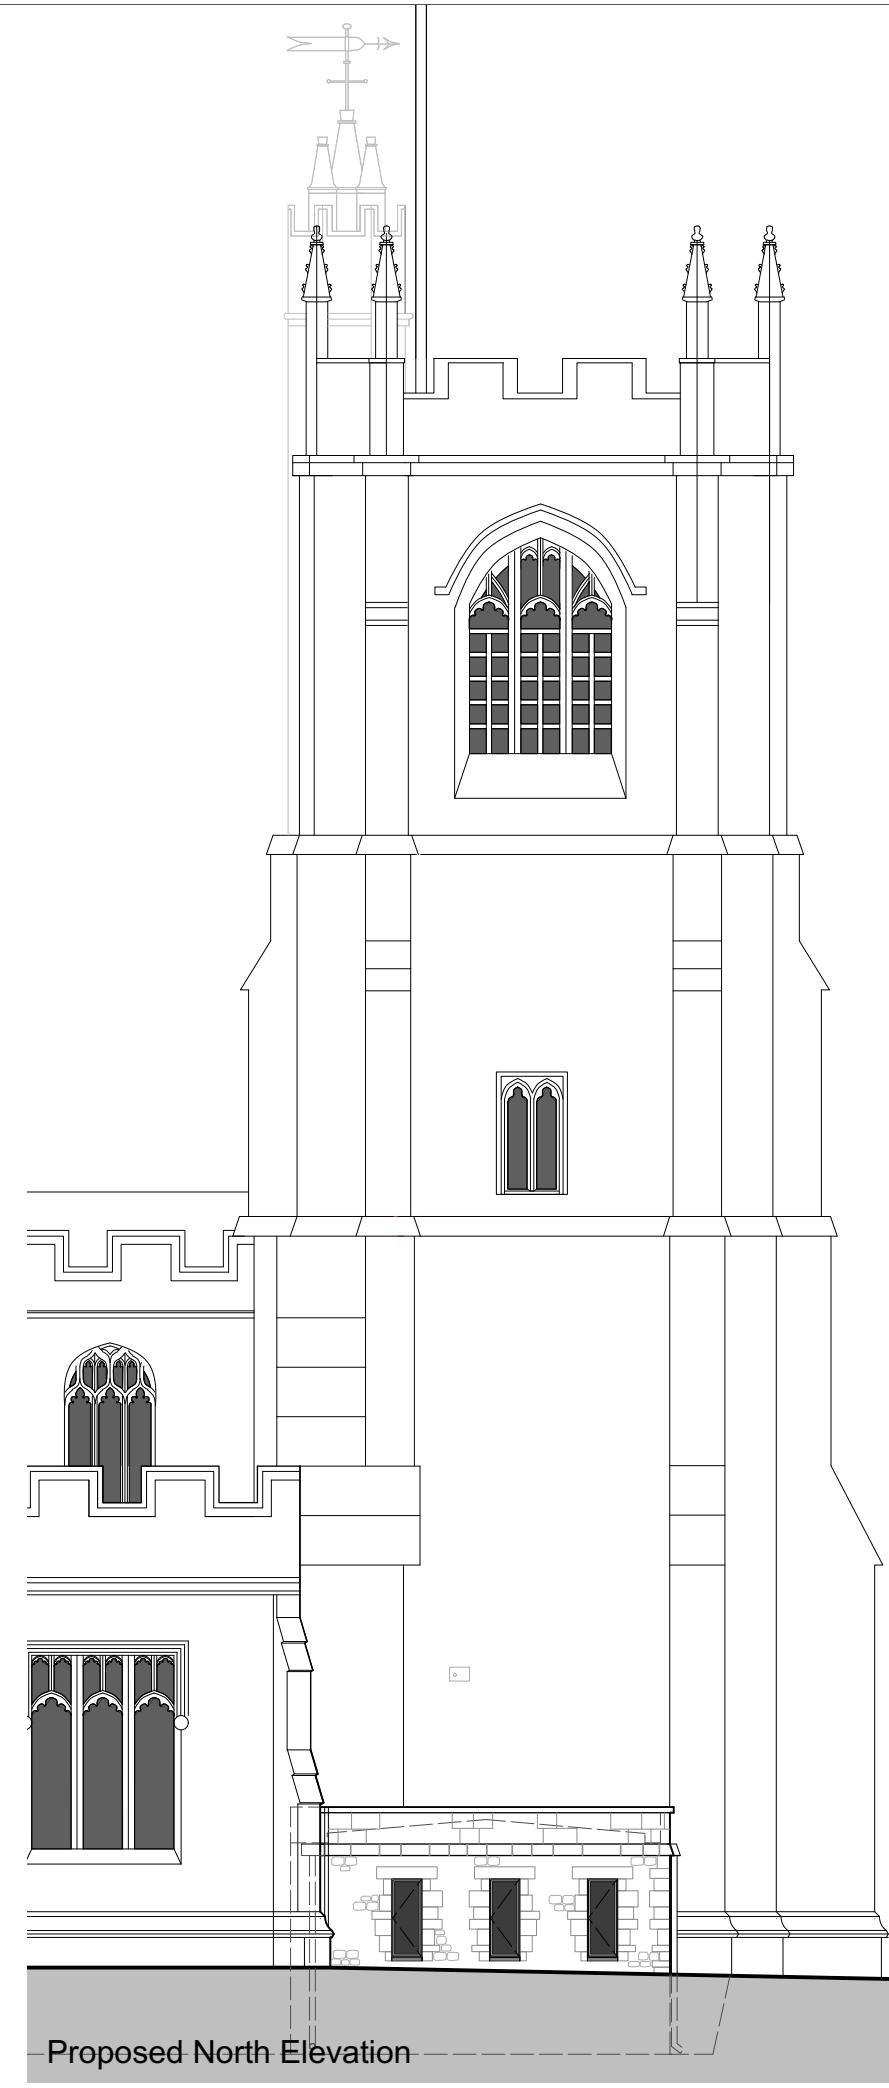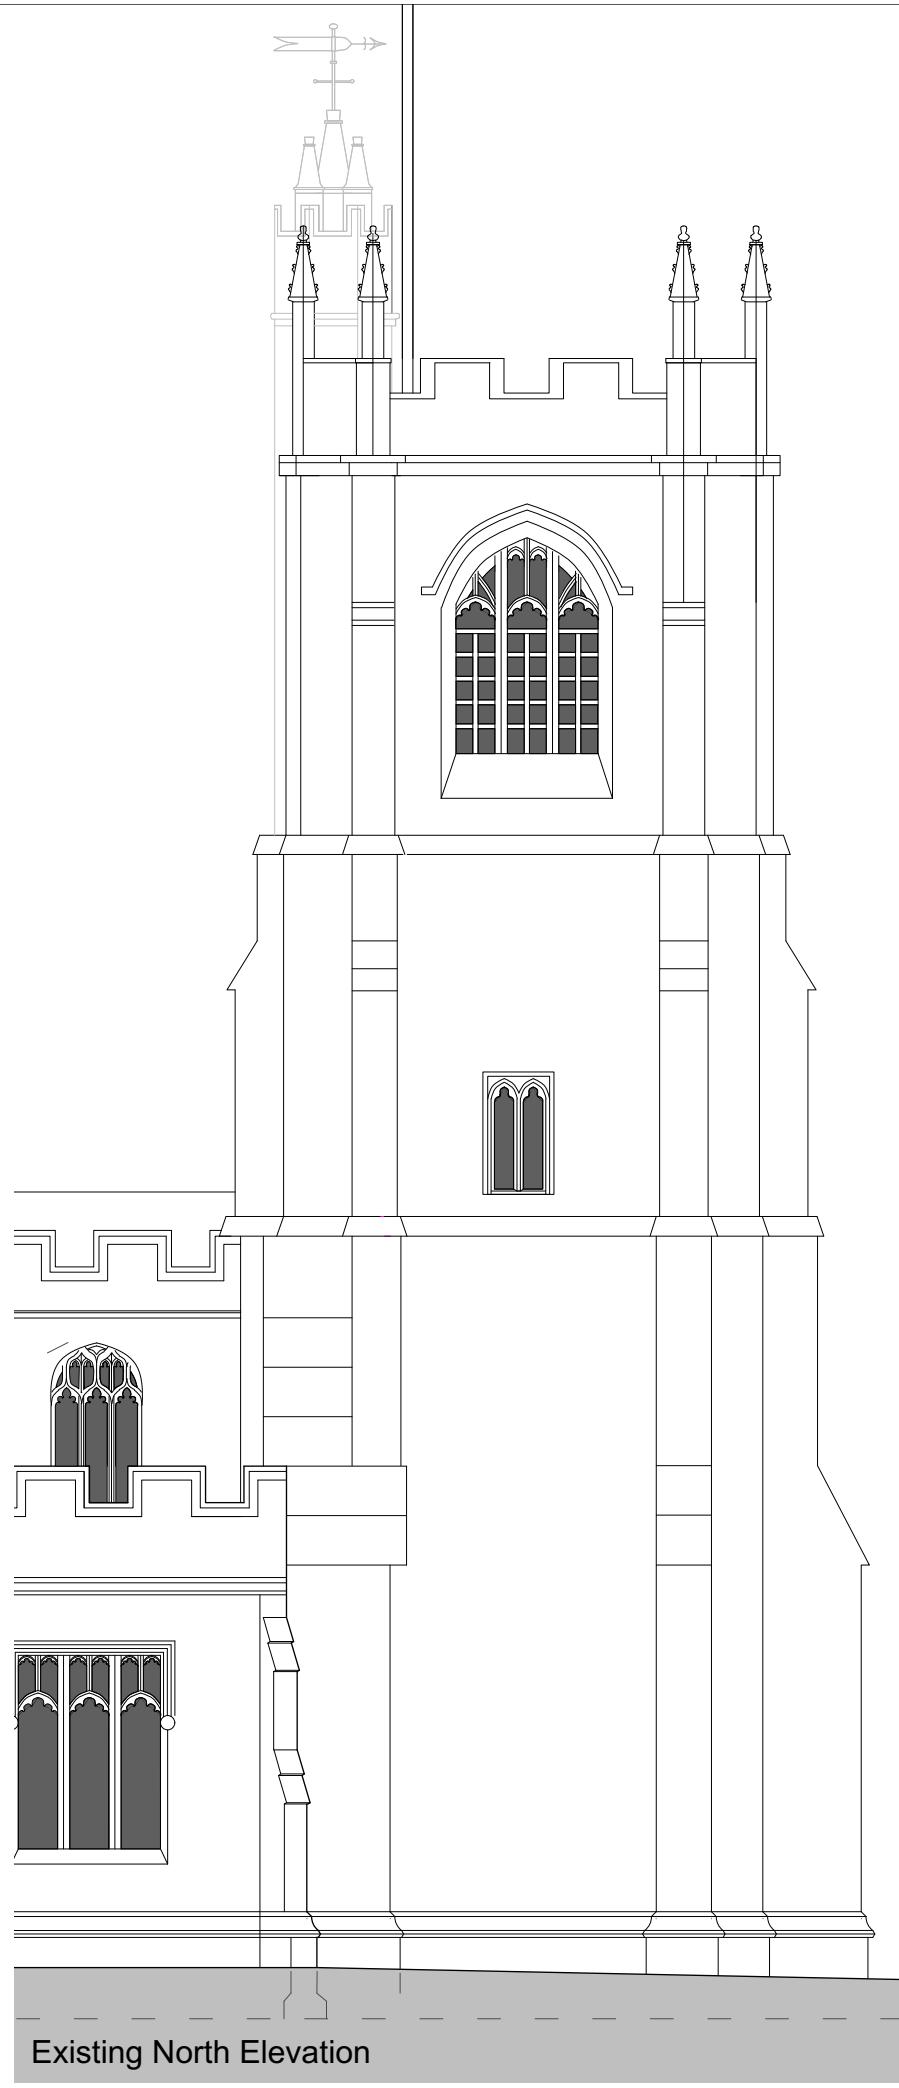


DATE \_\_\_\_\_


AMENDMENT: \_\_\_\_\_

Status	Faculty			
Job no / drawing no	Job title			
571-L-09	St Julians, Wellow			
Drawing title				
North Elevation - Existing and Proposed				
Date 18-03-20	Sheet A3	Scale 1:100	Drawn by HH	Checked by JH
All dimensions to be checked on site. Print Drawing in colour. Refer to CDM Sheet XXX/CDM				
www.hetreedross.com 01225 755867 Do not scale				

hetreed ross architects

**hra**

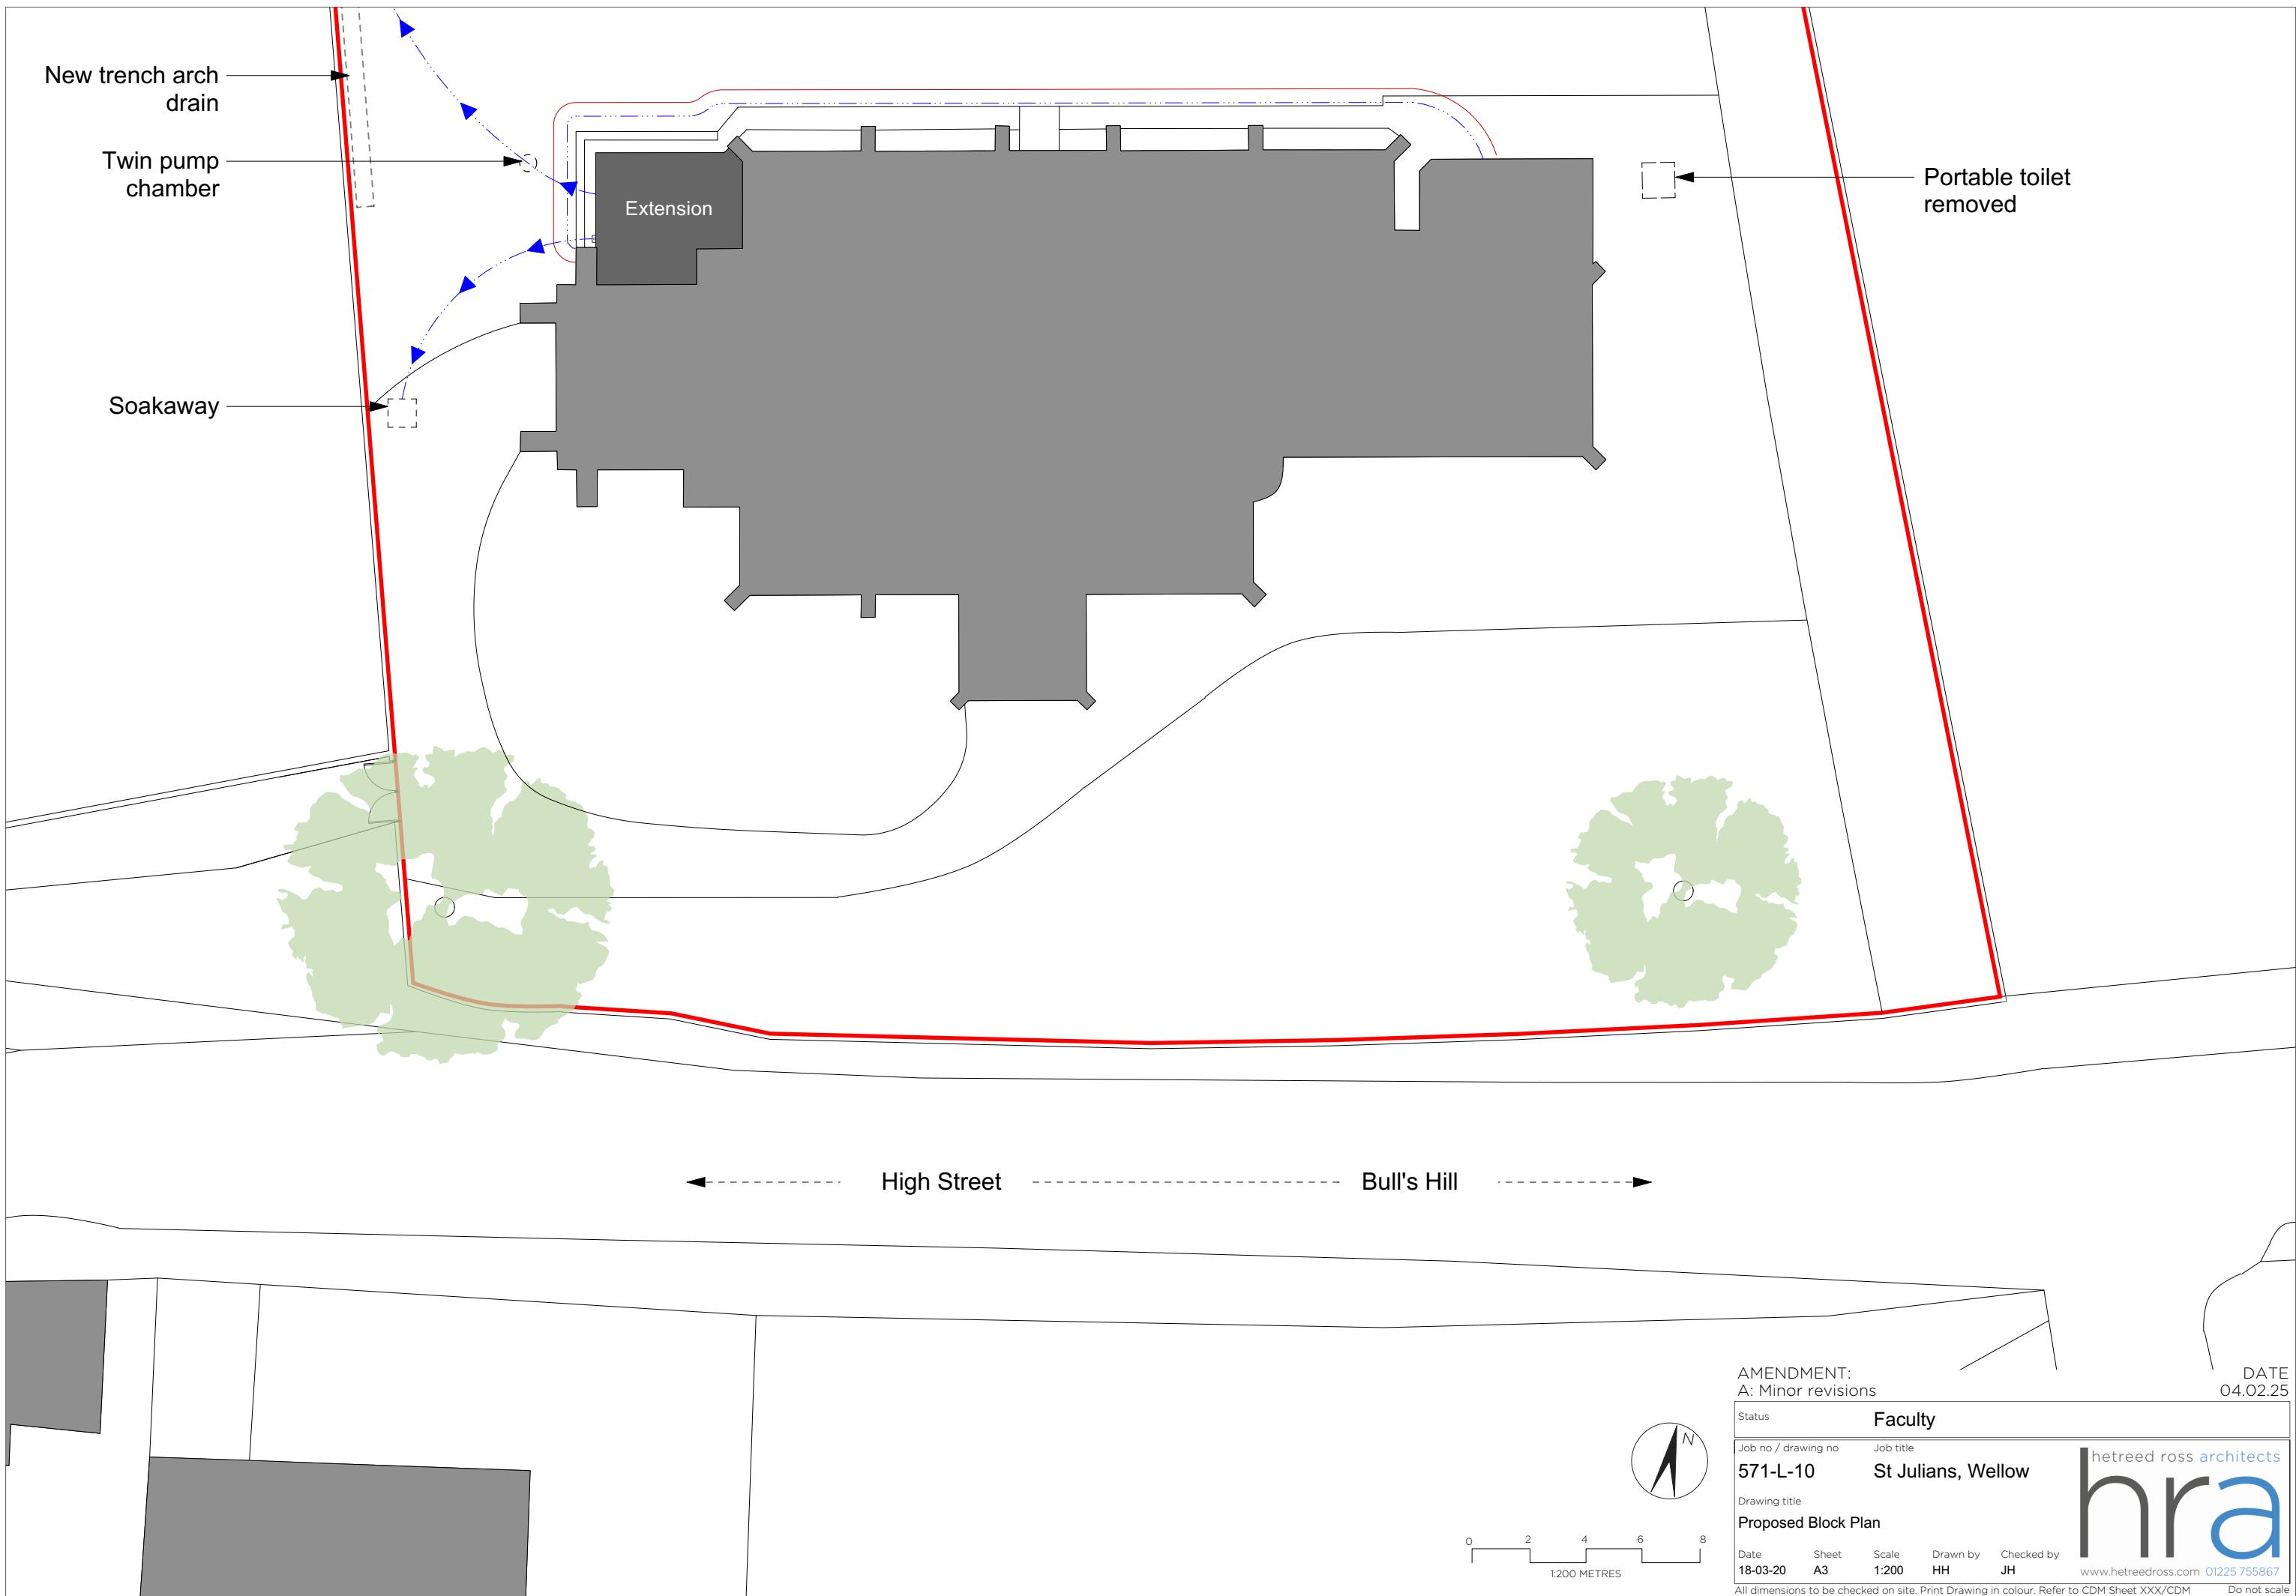

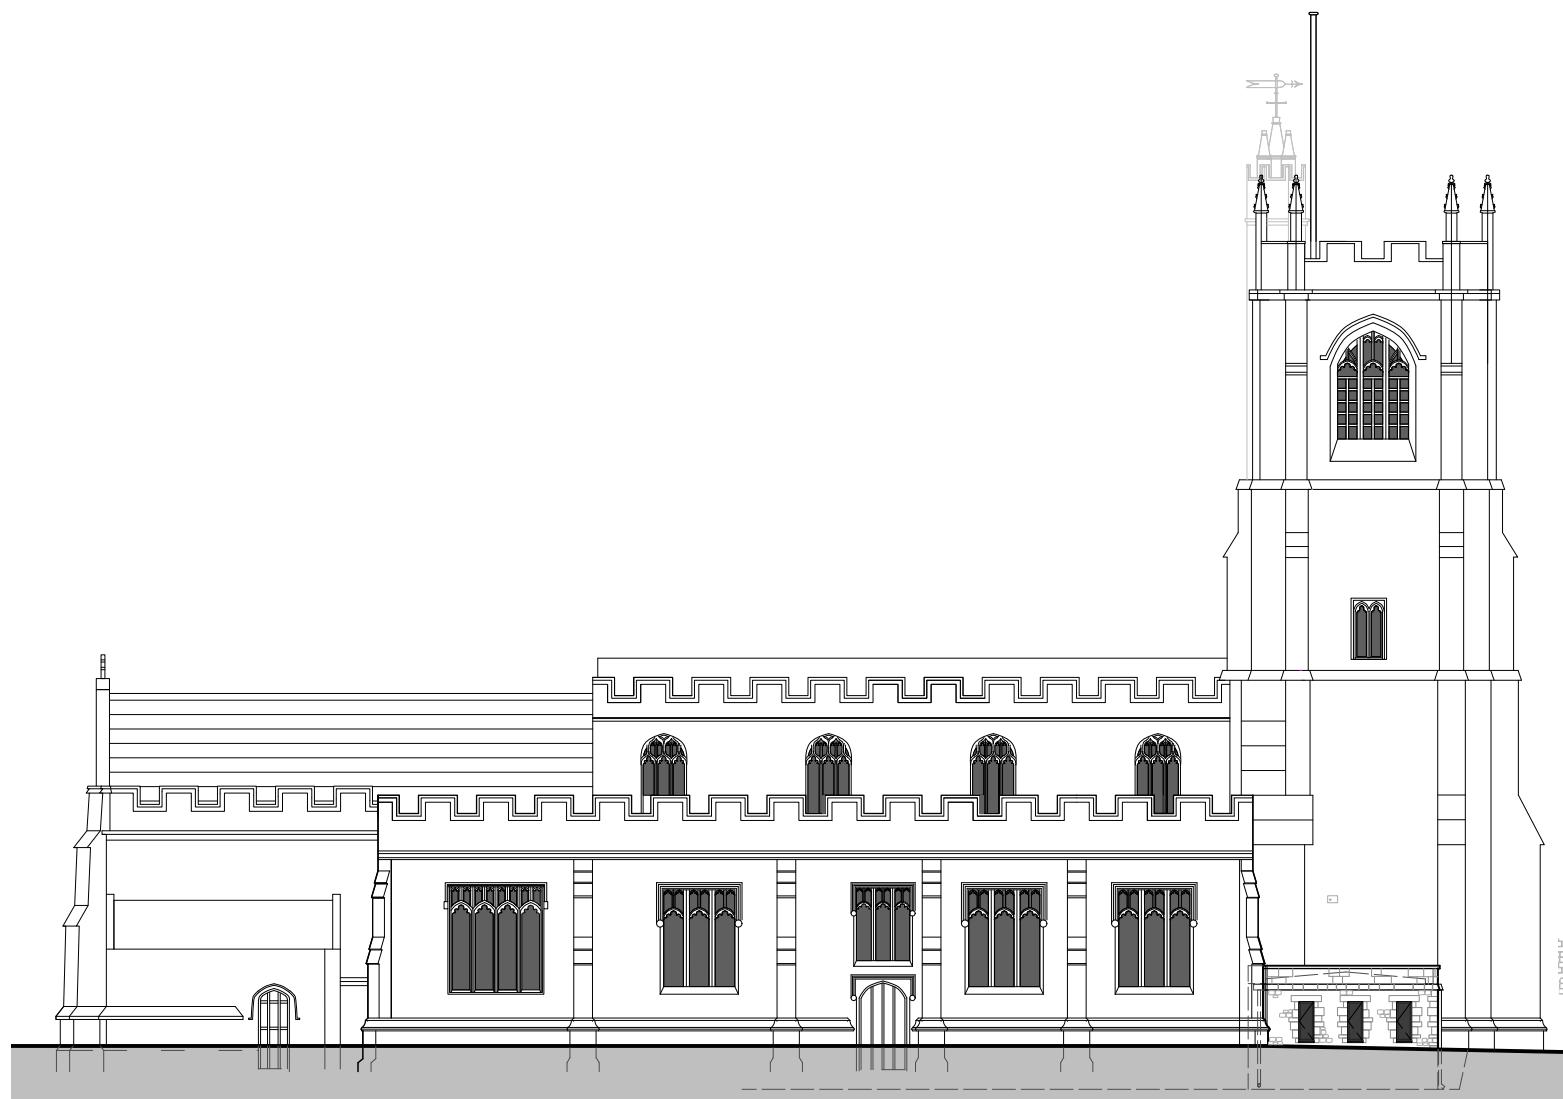

Proposed North Elevation



Proposed West Elevation

0 1 2 3 4  
1:100 METRES



AMENDMENT:

DATE

Status	Faculty			
Job no / drawing no	Job title			
<b>571-L-11</b>	<b>St Julians, Wellow</b>			
Drawing title				
Proposed Elevations				
Date 18-03-20	Sheet A3	Scale 1:100	Drawn by HH	Checked by JH


hetreed ross architects  
**hra**  
www.hetreedross.com 01225 755867

All dimensions to be checked on site. Print Drawing in colour. Refer to CDM Sheet XXX/CDM  
Do not scale

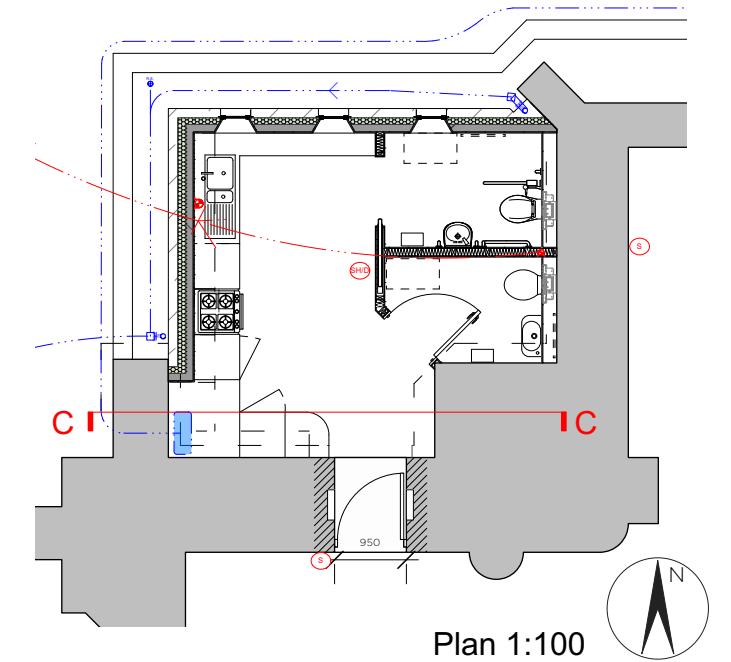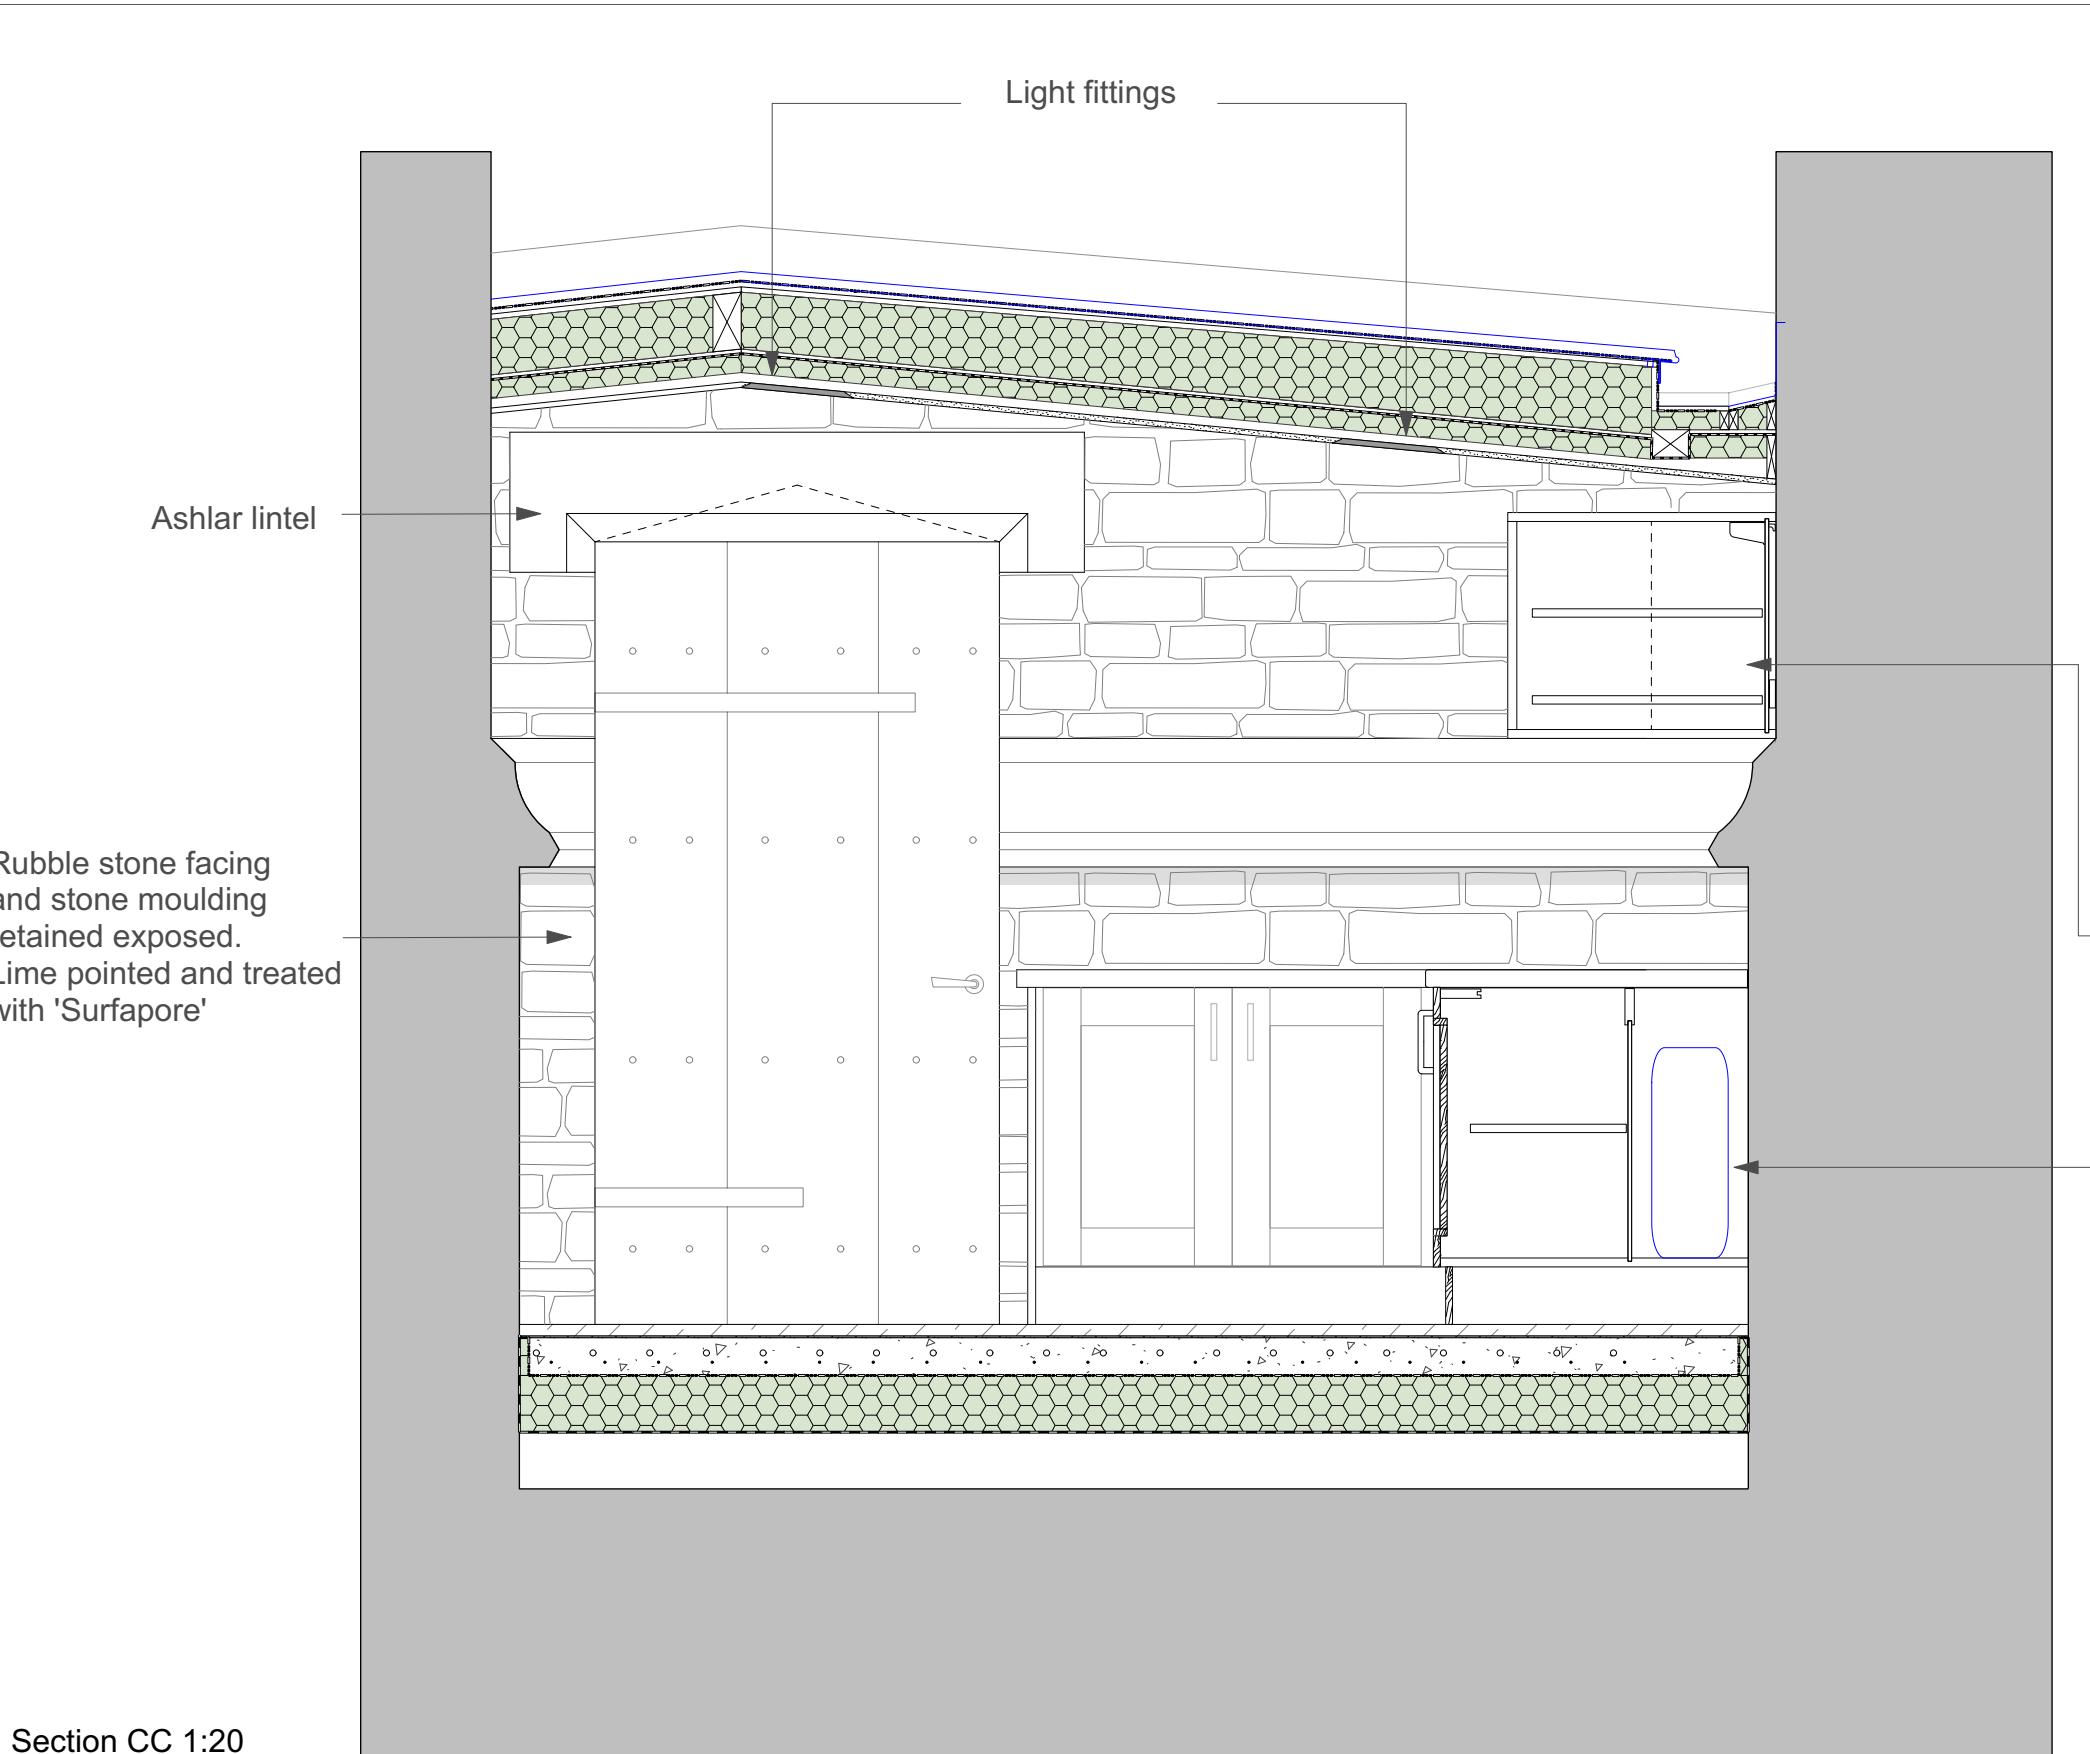

Standard depth overhead unit extended to buttress recess

Underfloor heating/hot water tank stored behind standard depth kitchen unit

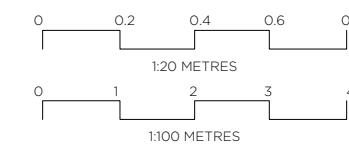



AMENDMENT:  
A: Doorway and roof amended

DATE  
04.02.25

Status	Faculty			
Job no / drawing no	Job title			
<b>571-L-12</b>	St Julians, Wellow			
Drawing title				
<b>Proposed Section CC</b>				
Date 18-03-20	Sheet A3	Scale 1:100	Drawn by HH	Checked by JH

hetreed ross architects  
**hra**  
www.hetreedross.com 01225 755867

All dimensions to be checked on site. Print Drawing in colour. Refer to CDM Sheet XXX/CDM Do not scale

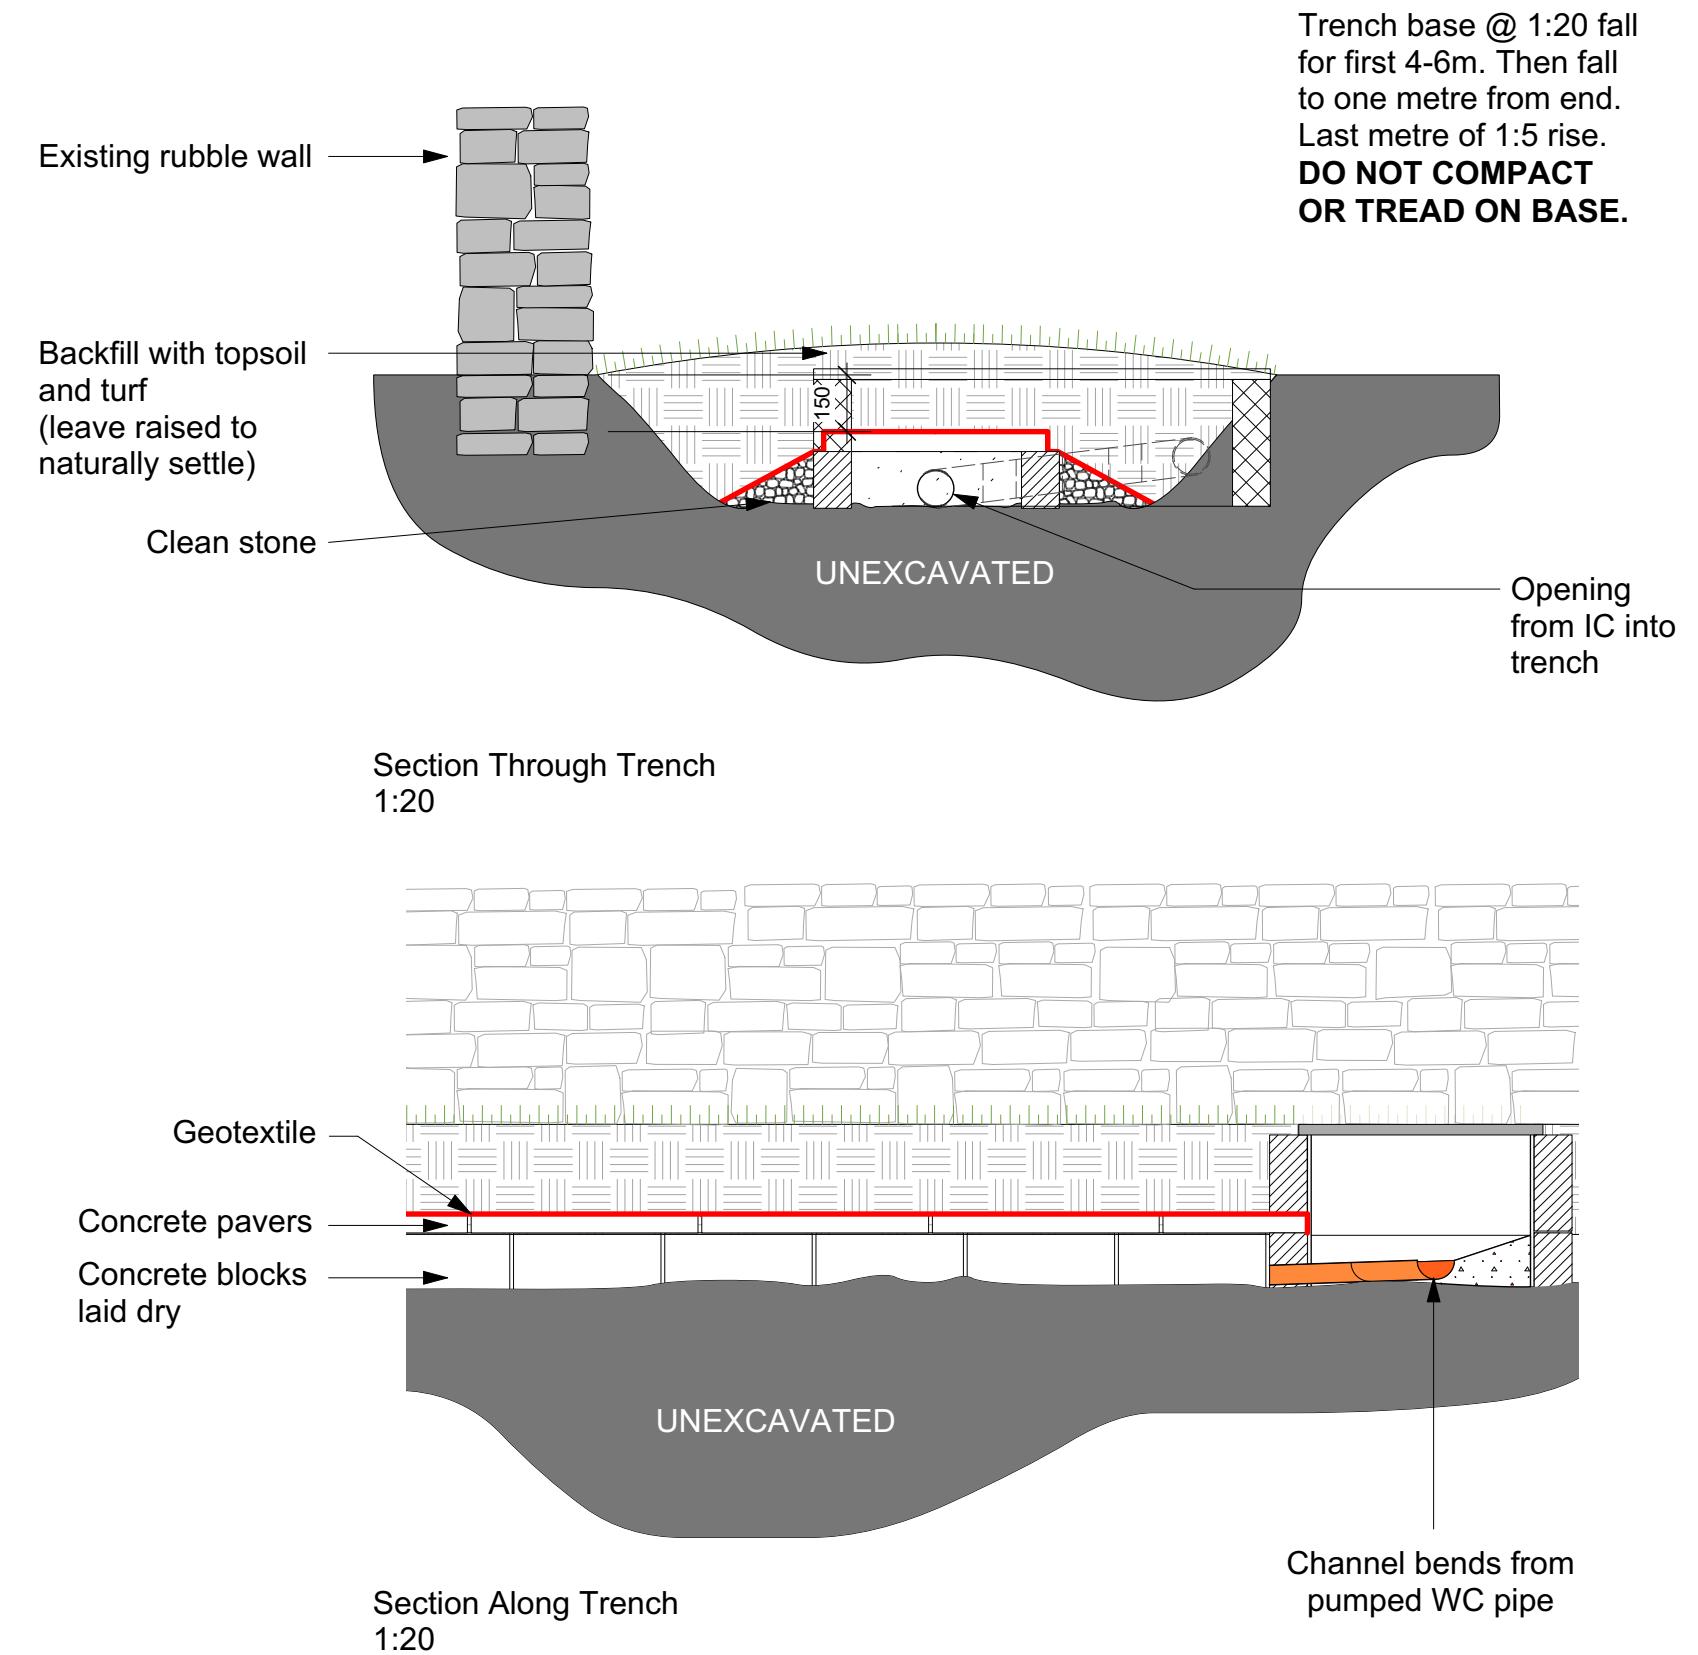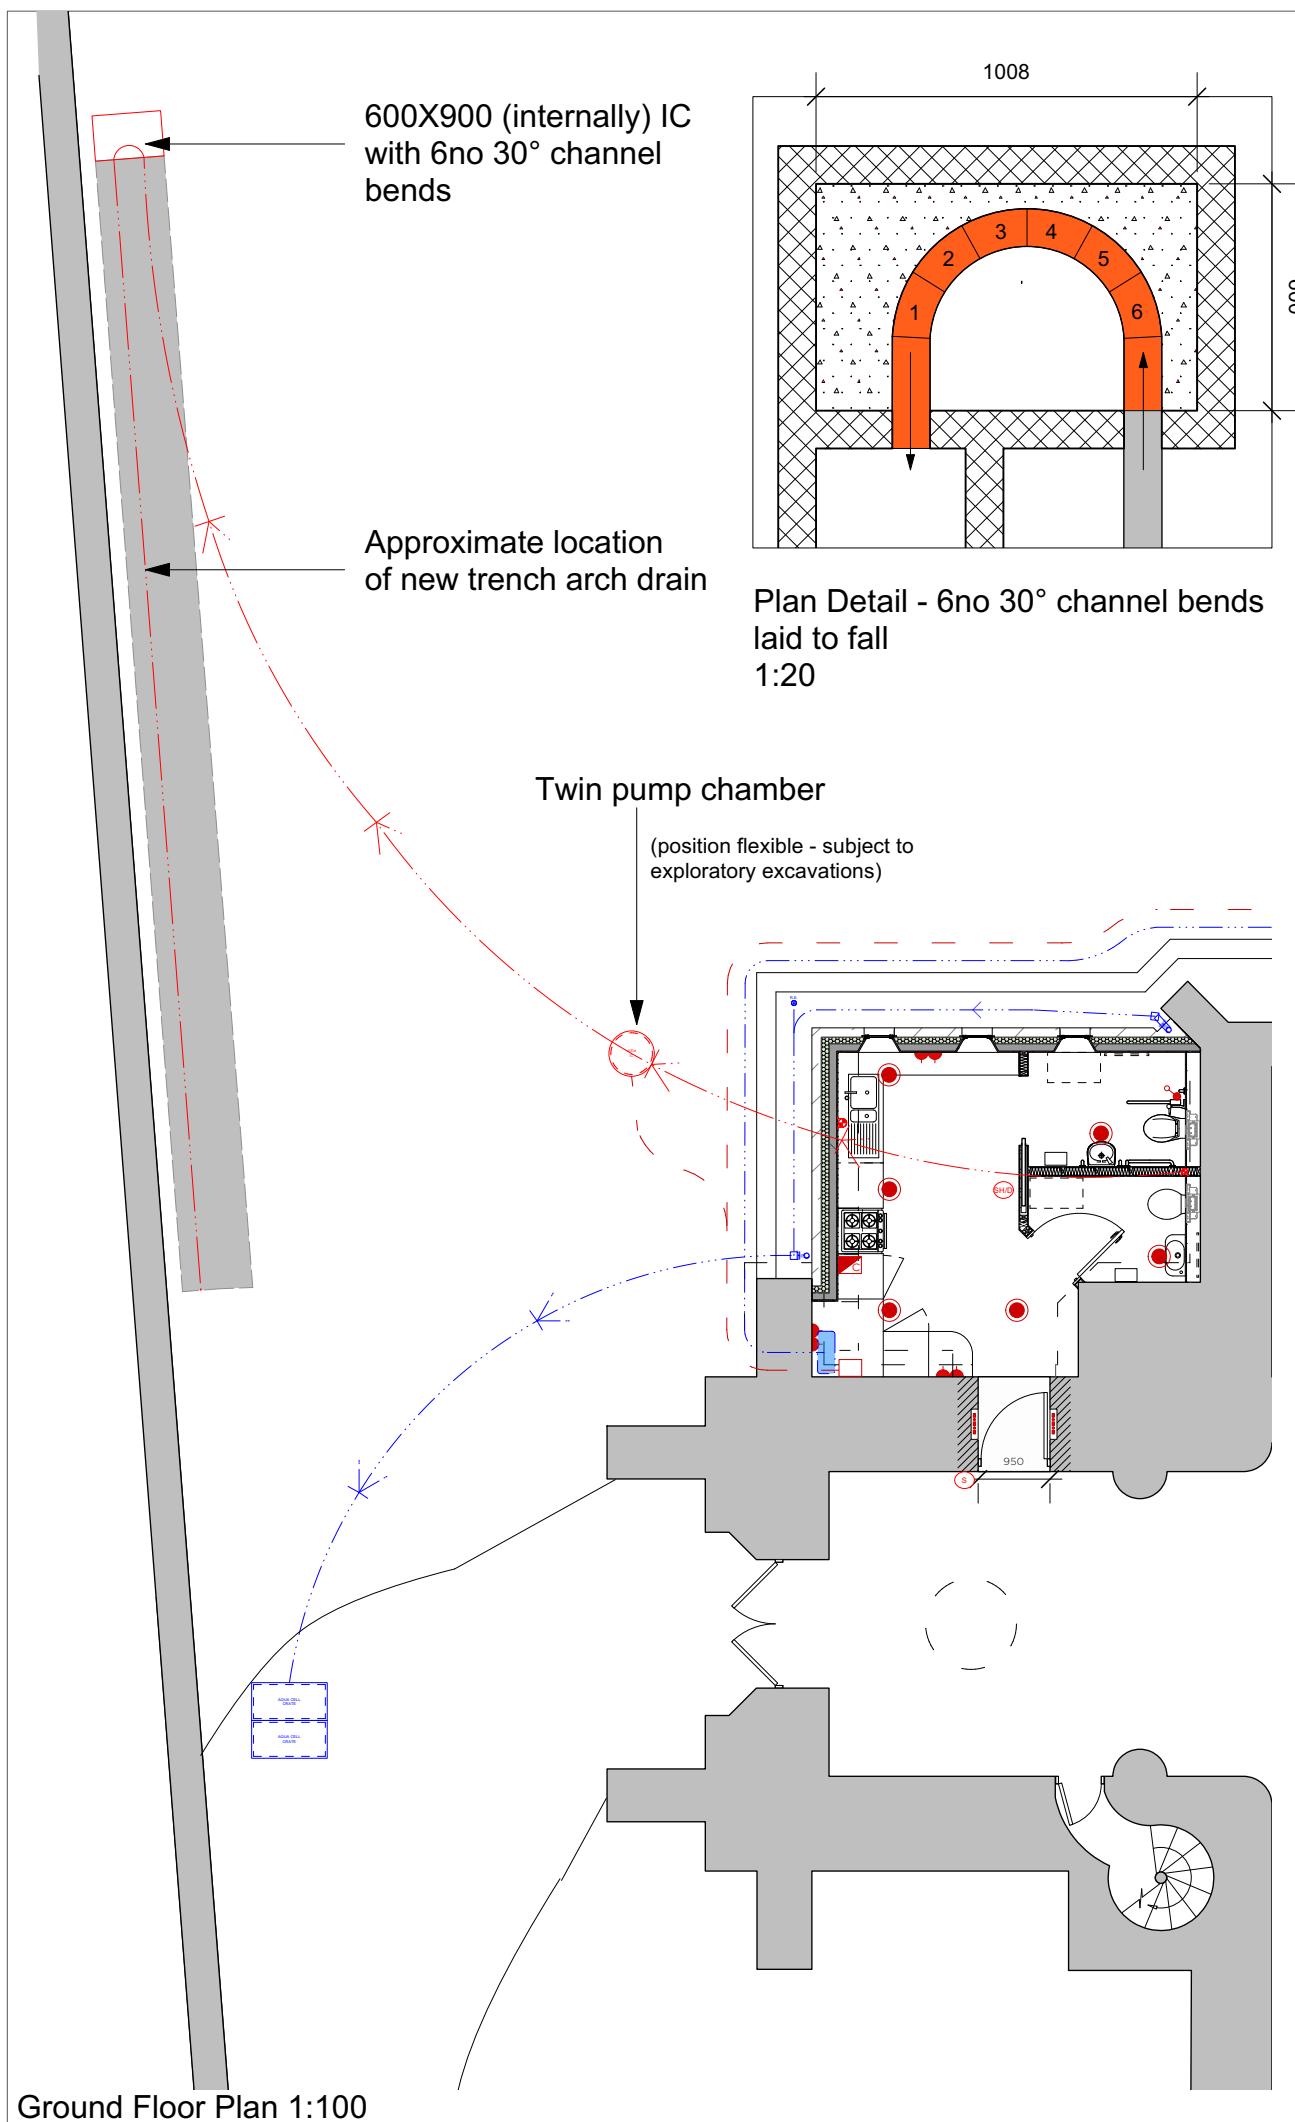



AMENDMENT:		DATE:		
Status	Faculty			
Job no / drawing no	Job title			
571-L-13	St Julians, Wellow			
Drawing title				
Proposed Trench Arch				
Date	Sheet	Scale	Drawn by	Checked by
12-02-20	A3	1:100 1:50	MS	JH
All dimensions to be checked on site. Print Drawing in colour. Refer to CDM Sheet XXX/CDM				

hetreed ross architects


hra

www.hetreedross.com 01225 755867

Do not scale

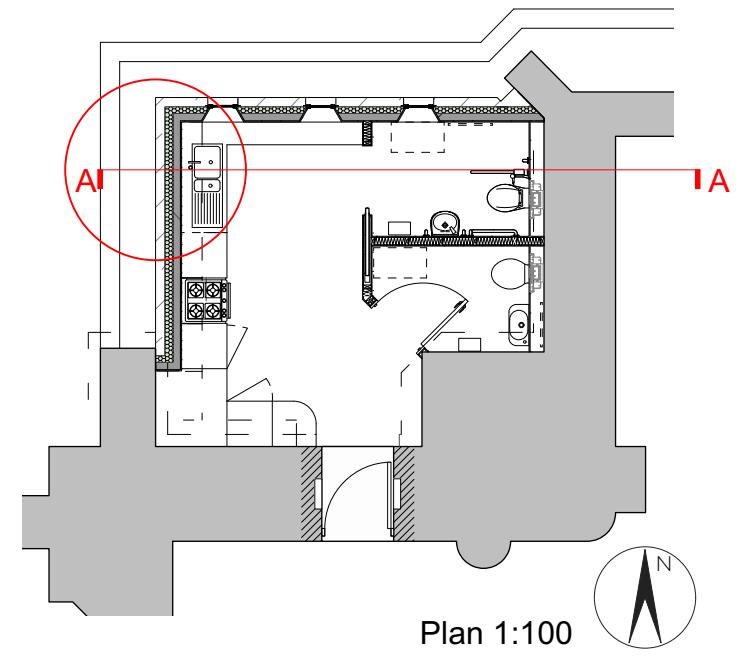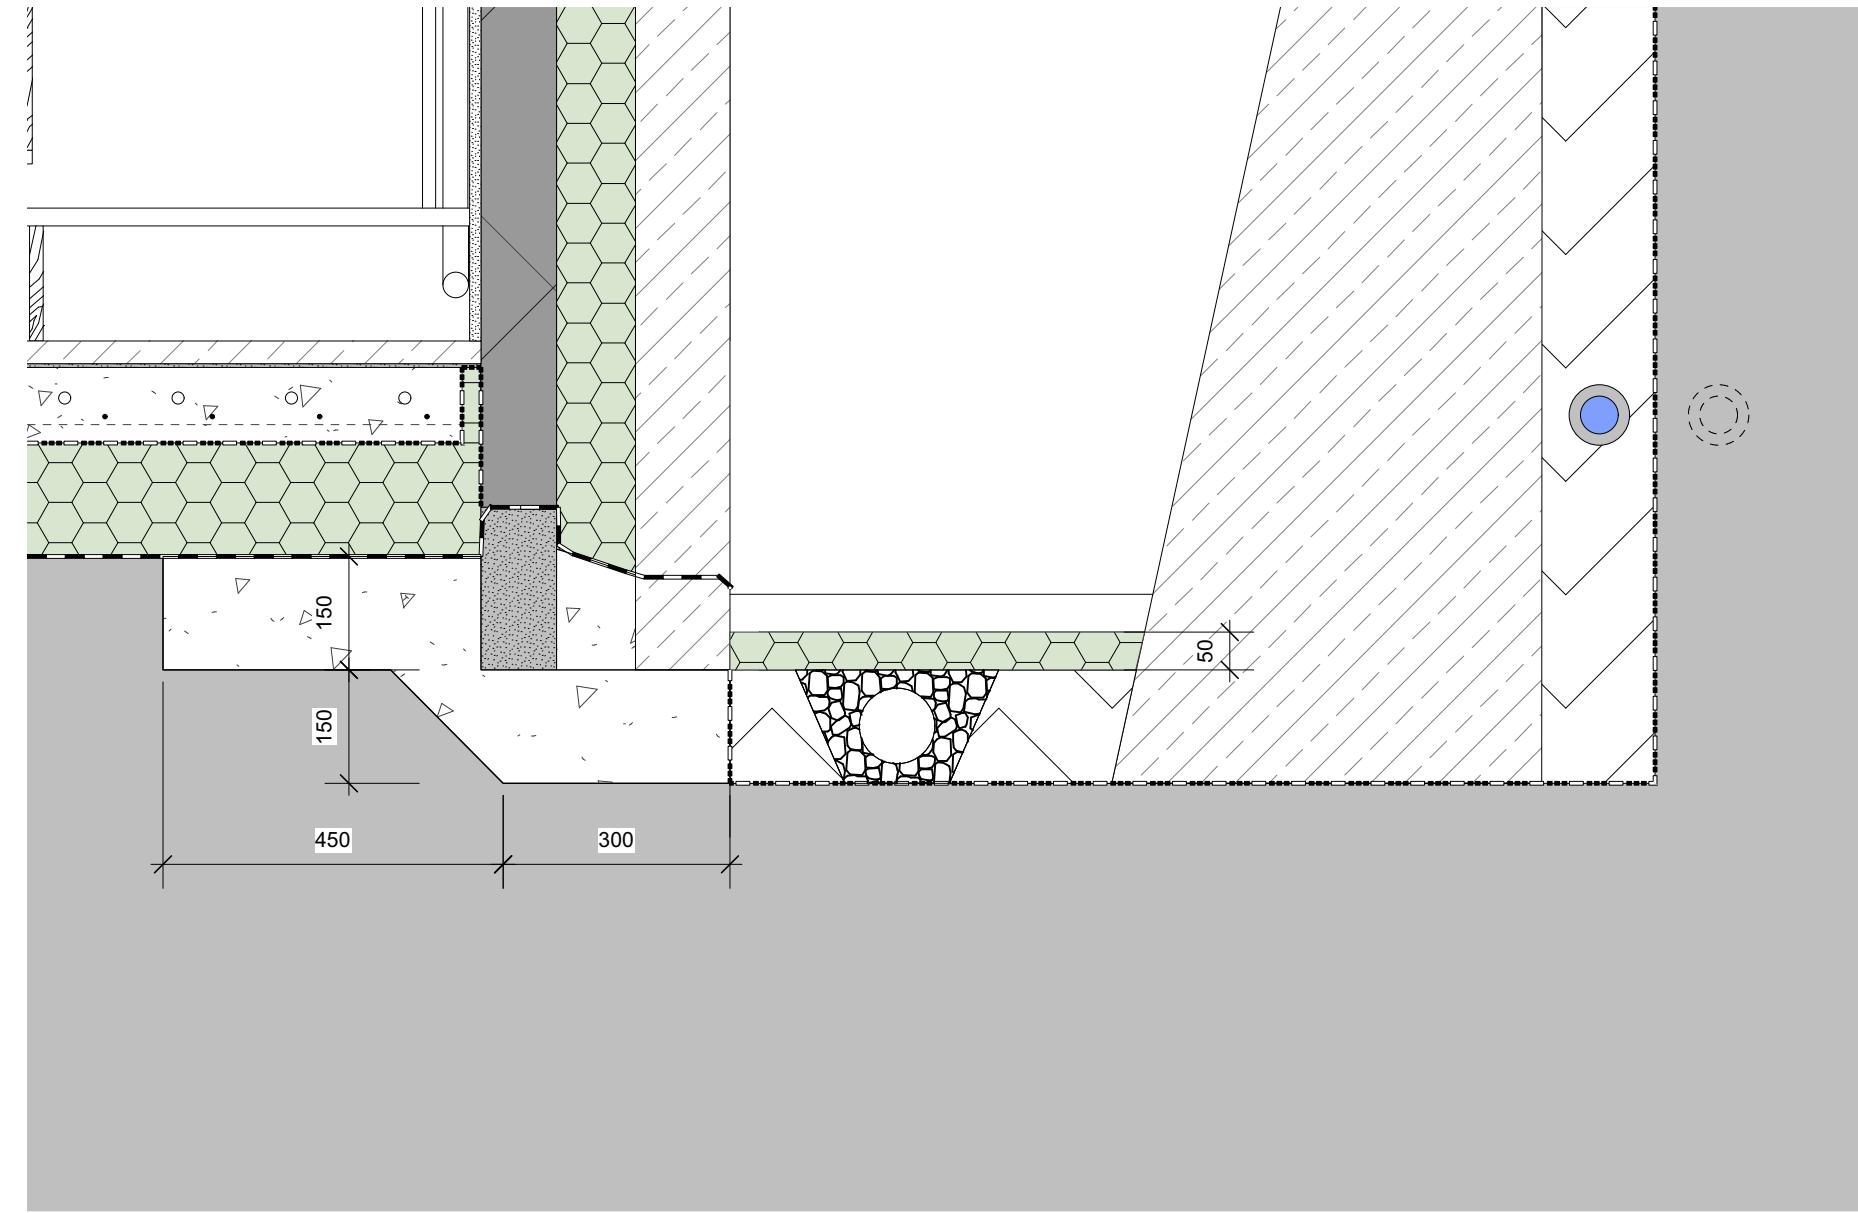

AMENDMENT:		DATE		
Status	Faculty			
Job no / drawing no	Job title			
<b>571-L-14</b>	St Julians, Wellow			
Drawing title				
<b>Proposed Section AA</b>				
Date	Sheet	Scale	Drawn by	Checked by
12-02-20	A3	1:100 1:20	MS	JH
All dimensions to be checked on site. Print Drawing in colour. Refer to CDM Sheet XXX/CDM				
 <a href="http://www.hetreedross.com">www.hetreedross.com</a> 01225 755867				

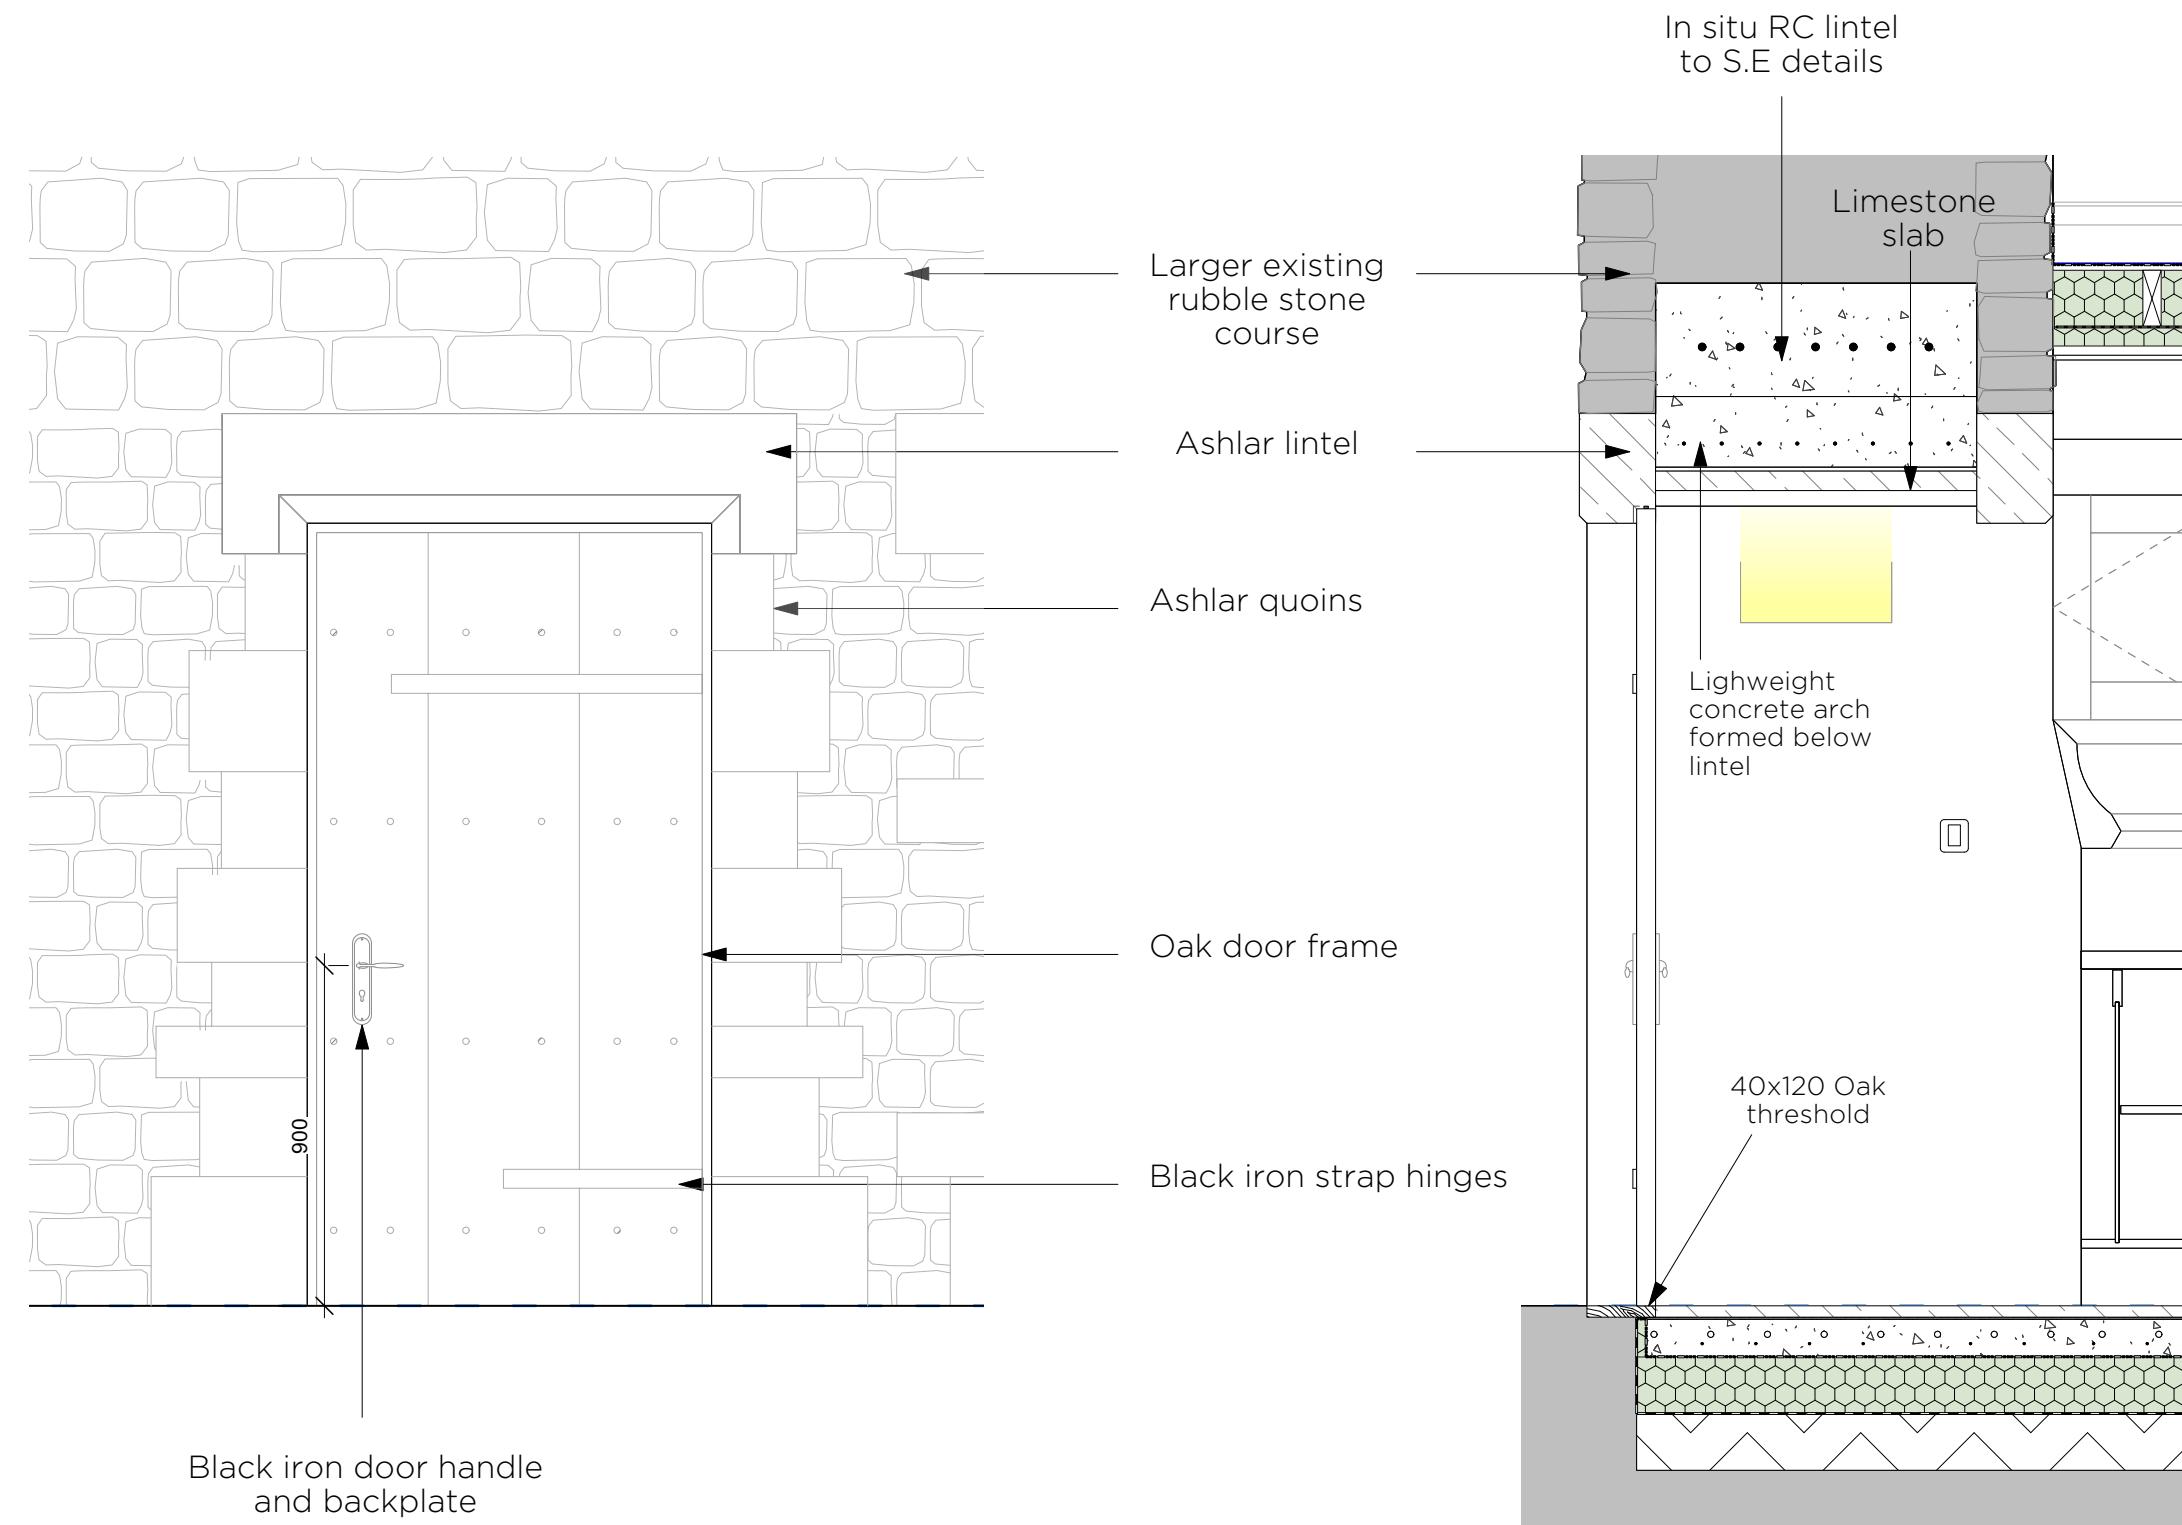

0 0.2 0.4 0.6 0.8  
1:20 METRES

Status	Faculty			
Job no / drawing no	Job title			
<b>571-L-15</b>	St Julians, Wellow			
Drawing title				
<b>Proposed Tower Door Details</b>				
Date	Sheet	Scale	Drawn by	Checked by
02.09.2025	A3	1:20	JS	JH
All dimensions to be checked on site. Print Drawing in colour. Refer to CDM Sheet XXX/CDM				

hetreed ross architects

**hra**

www.hetreedross.com 01225 755867

Do not scale




LED recessed downlight 12W  
ultra-thin (10mm installation) warm  
white (3000k) 300mmØ



MLS 2x LED linear strip in warm white

**NOTE:**  
Rooflight omitted since planning stage therefore no light spill shall be created upwards onto the tower. No new external lighting is proposed.

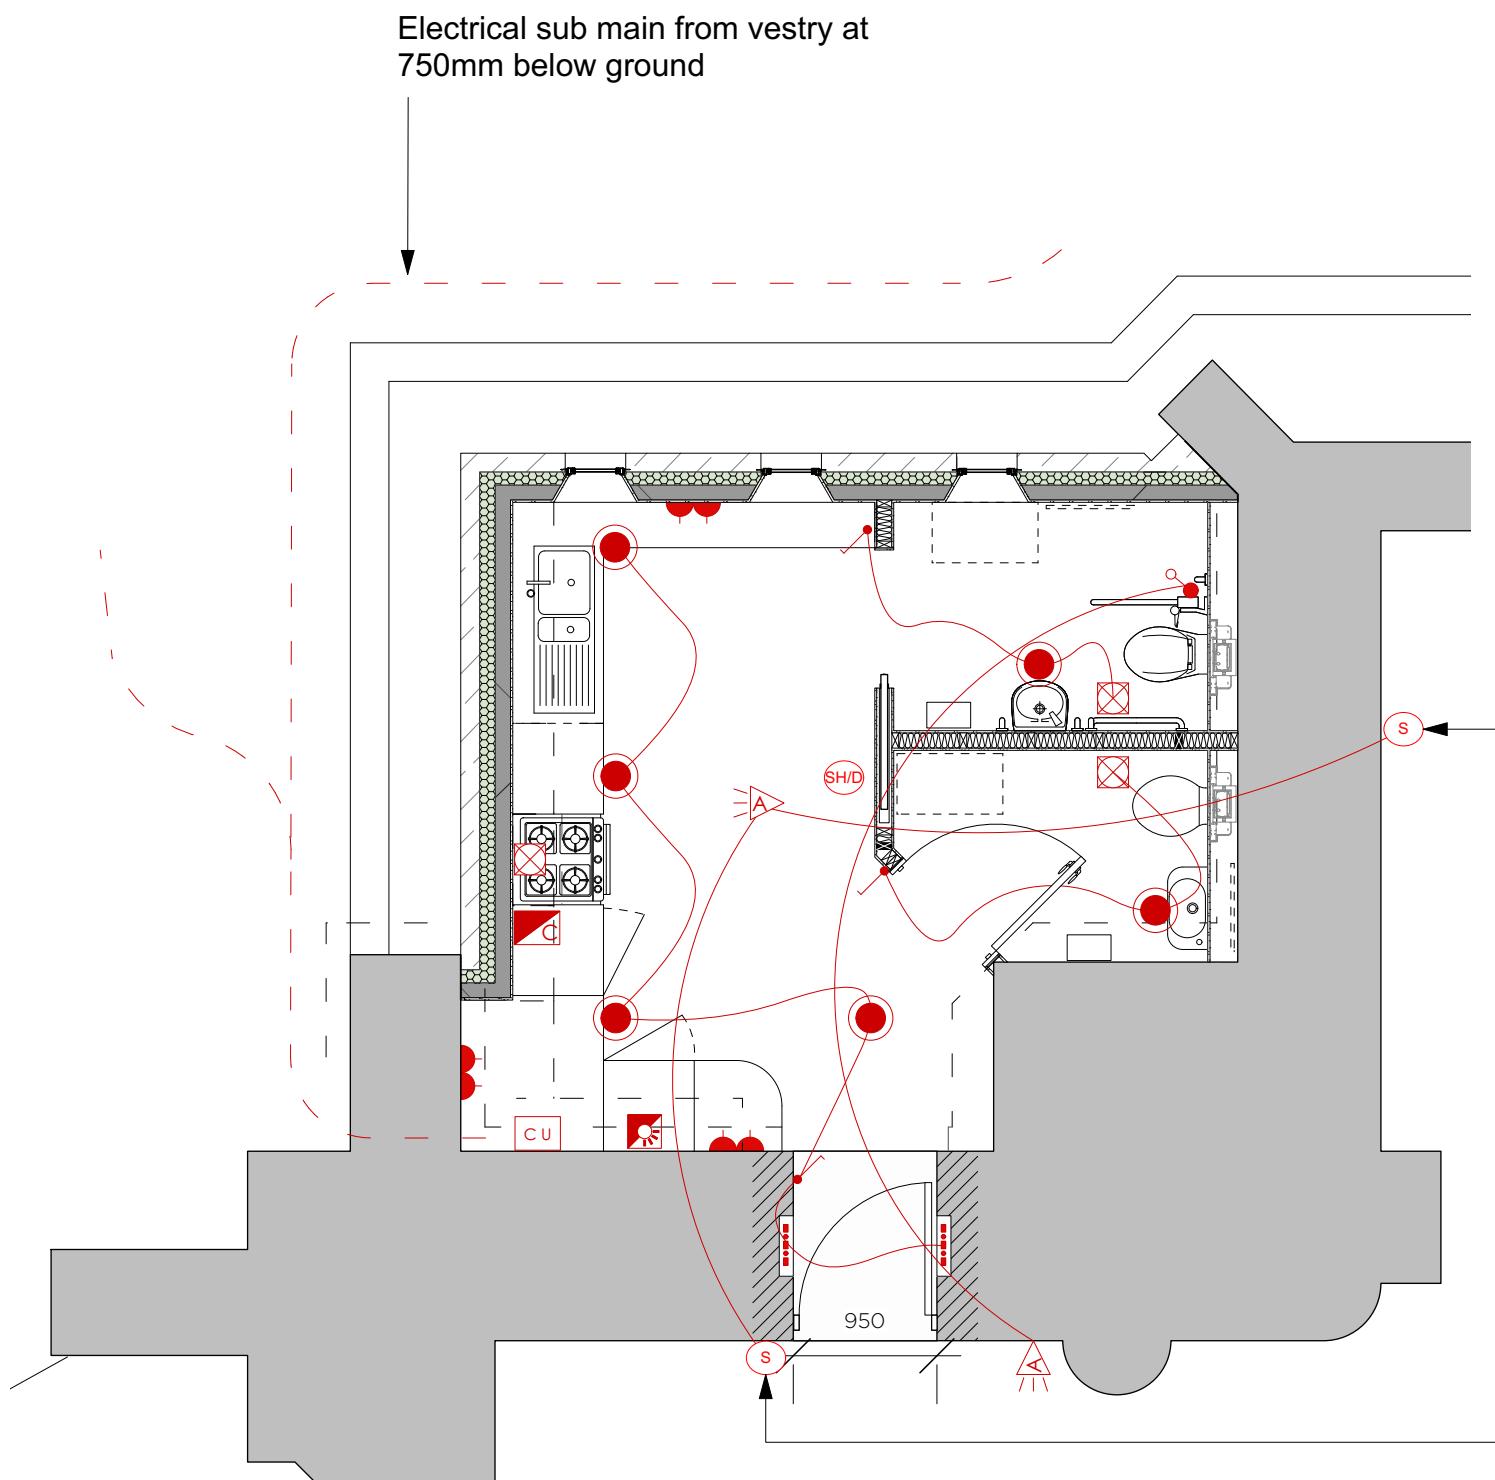

#### LIGHTING AND ELECTRICAL KEY

●	FIXED RECESSED CEILING FITTING
---	LED STRING
●	LIGHT SWITCH
CU	CONSUMER UNIT
SH/D	MAINS WIRED SMOKE & HEAT DETECTOR
S	MAINS WIRED SMOKE DETECTOR
●	EMERGENCY PULL CHORD
A	AUDIO AND VISUAL EMERGENCY ALARM
CE	CEILING FIXED MECHANICAL EXTRACTOR
SW	SWITCHED FUSED SPUR WITH LIT INDICATOR
30A	30AMP COOKER FUSED SPUR
HW	HIGH LEVEL WALL MOUNT TWIN SOCKET

AMENDMENT:

A - Smoke detectors and alarm added

DATE:


11/09/2025

0 0.5 1 1.5 2  
1:50 METRES



Status	Faculty
Job no / drawing no	Job title
<b>571-L-16A</b>	
St Julians, Wellow	
Drawing title	Proposed Electrical Layout
Date	Sheet
02.09.2025	Scale
	1:50
Drawn by	Checked by
JS	JH
All dimensions to be checked on site. Print Drawing in colour. Refer to CDM Sheet XXX/CDM	
www.hetreedross.com 01225 755867	
Do not scale	

**hra**  
hetreed ross architects  
www.hetreedross.com 01225 755867

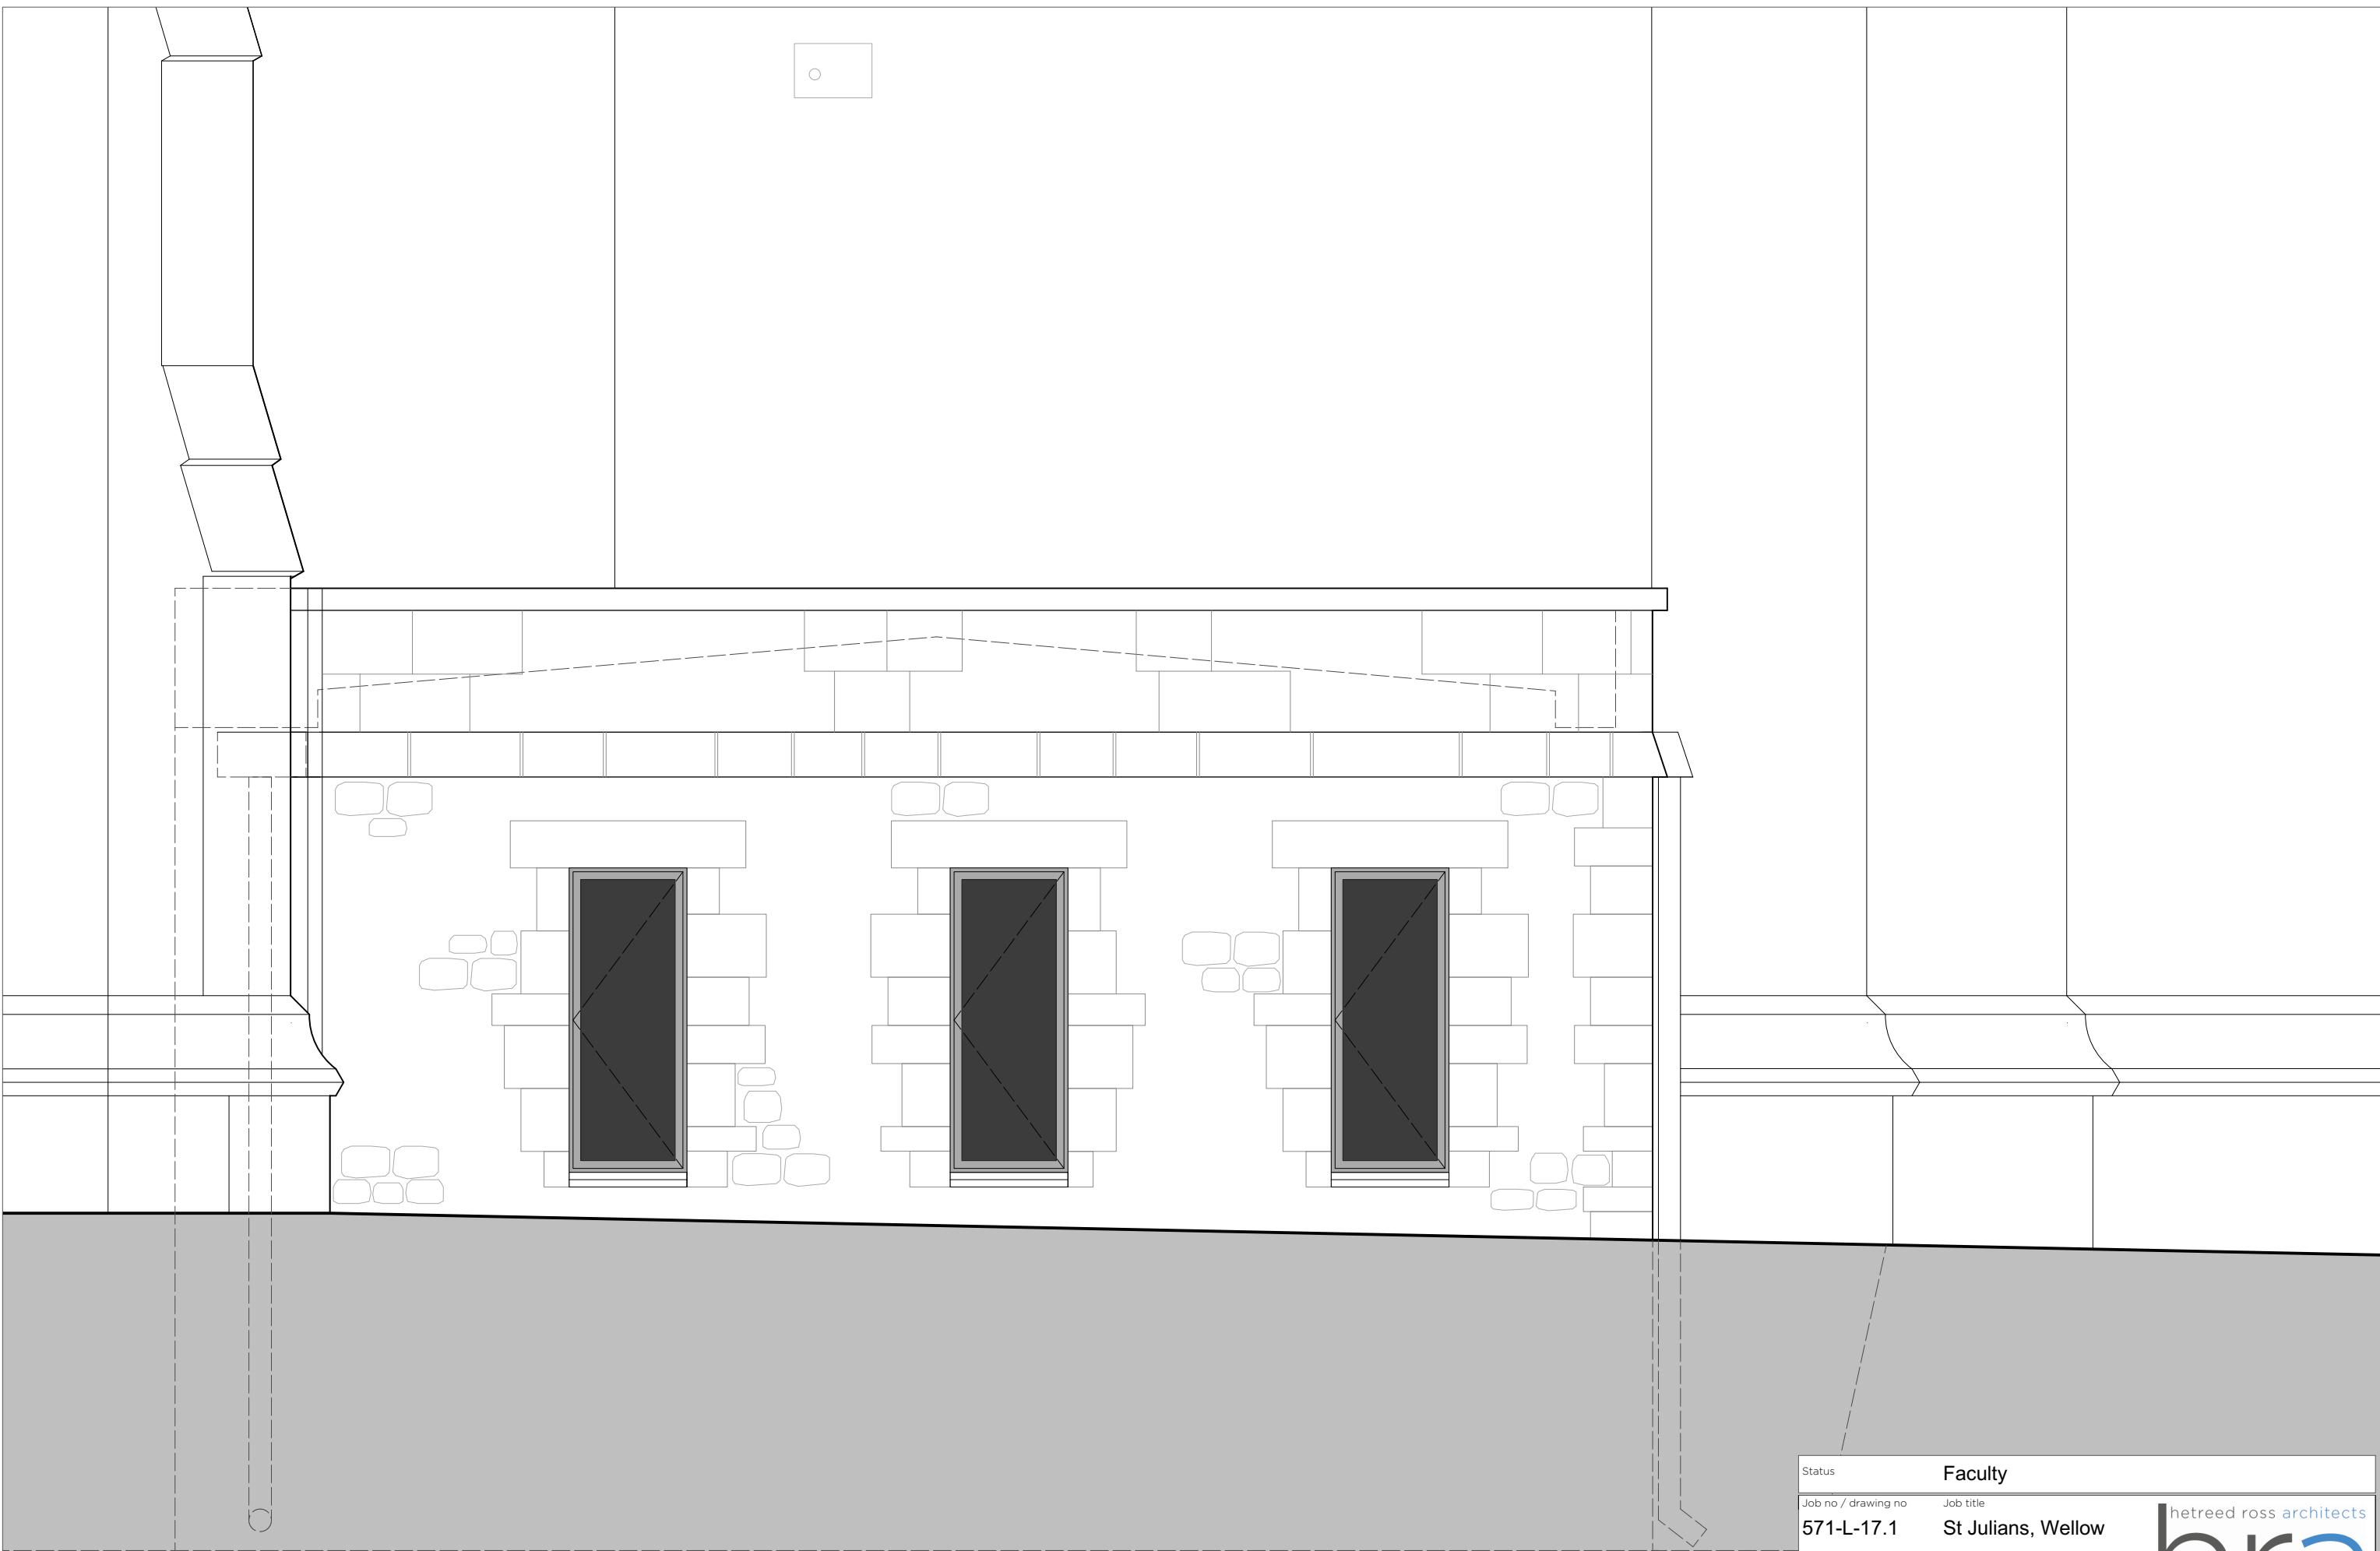


Proposed North Elevation



Scale 1:20

0 0.2 0.4 0.6 0.8  
1:20 METRES

Status Faculty  
Job no / drawing no Job title  
**571-L-17.1** **St Julians, Wellow**  
Drawing title  
**Proposed Detail Elevations (North)**  
Date Sheet Scale Drawn by Checked by  
02.09.2025 A3 1:20 JS JH  
All dimensions to be checked on site. Print Drawing in colour. Refer to CDM Sheet XXX/CDM  
www.hetreedross.com 01225 755867 Do not scale

hetreed ross architects  
**hra**

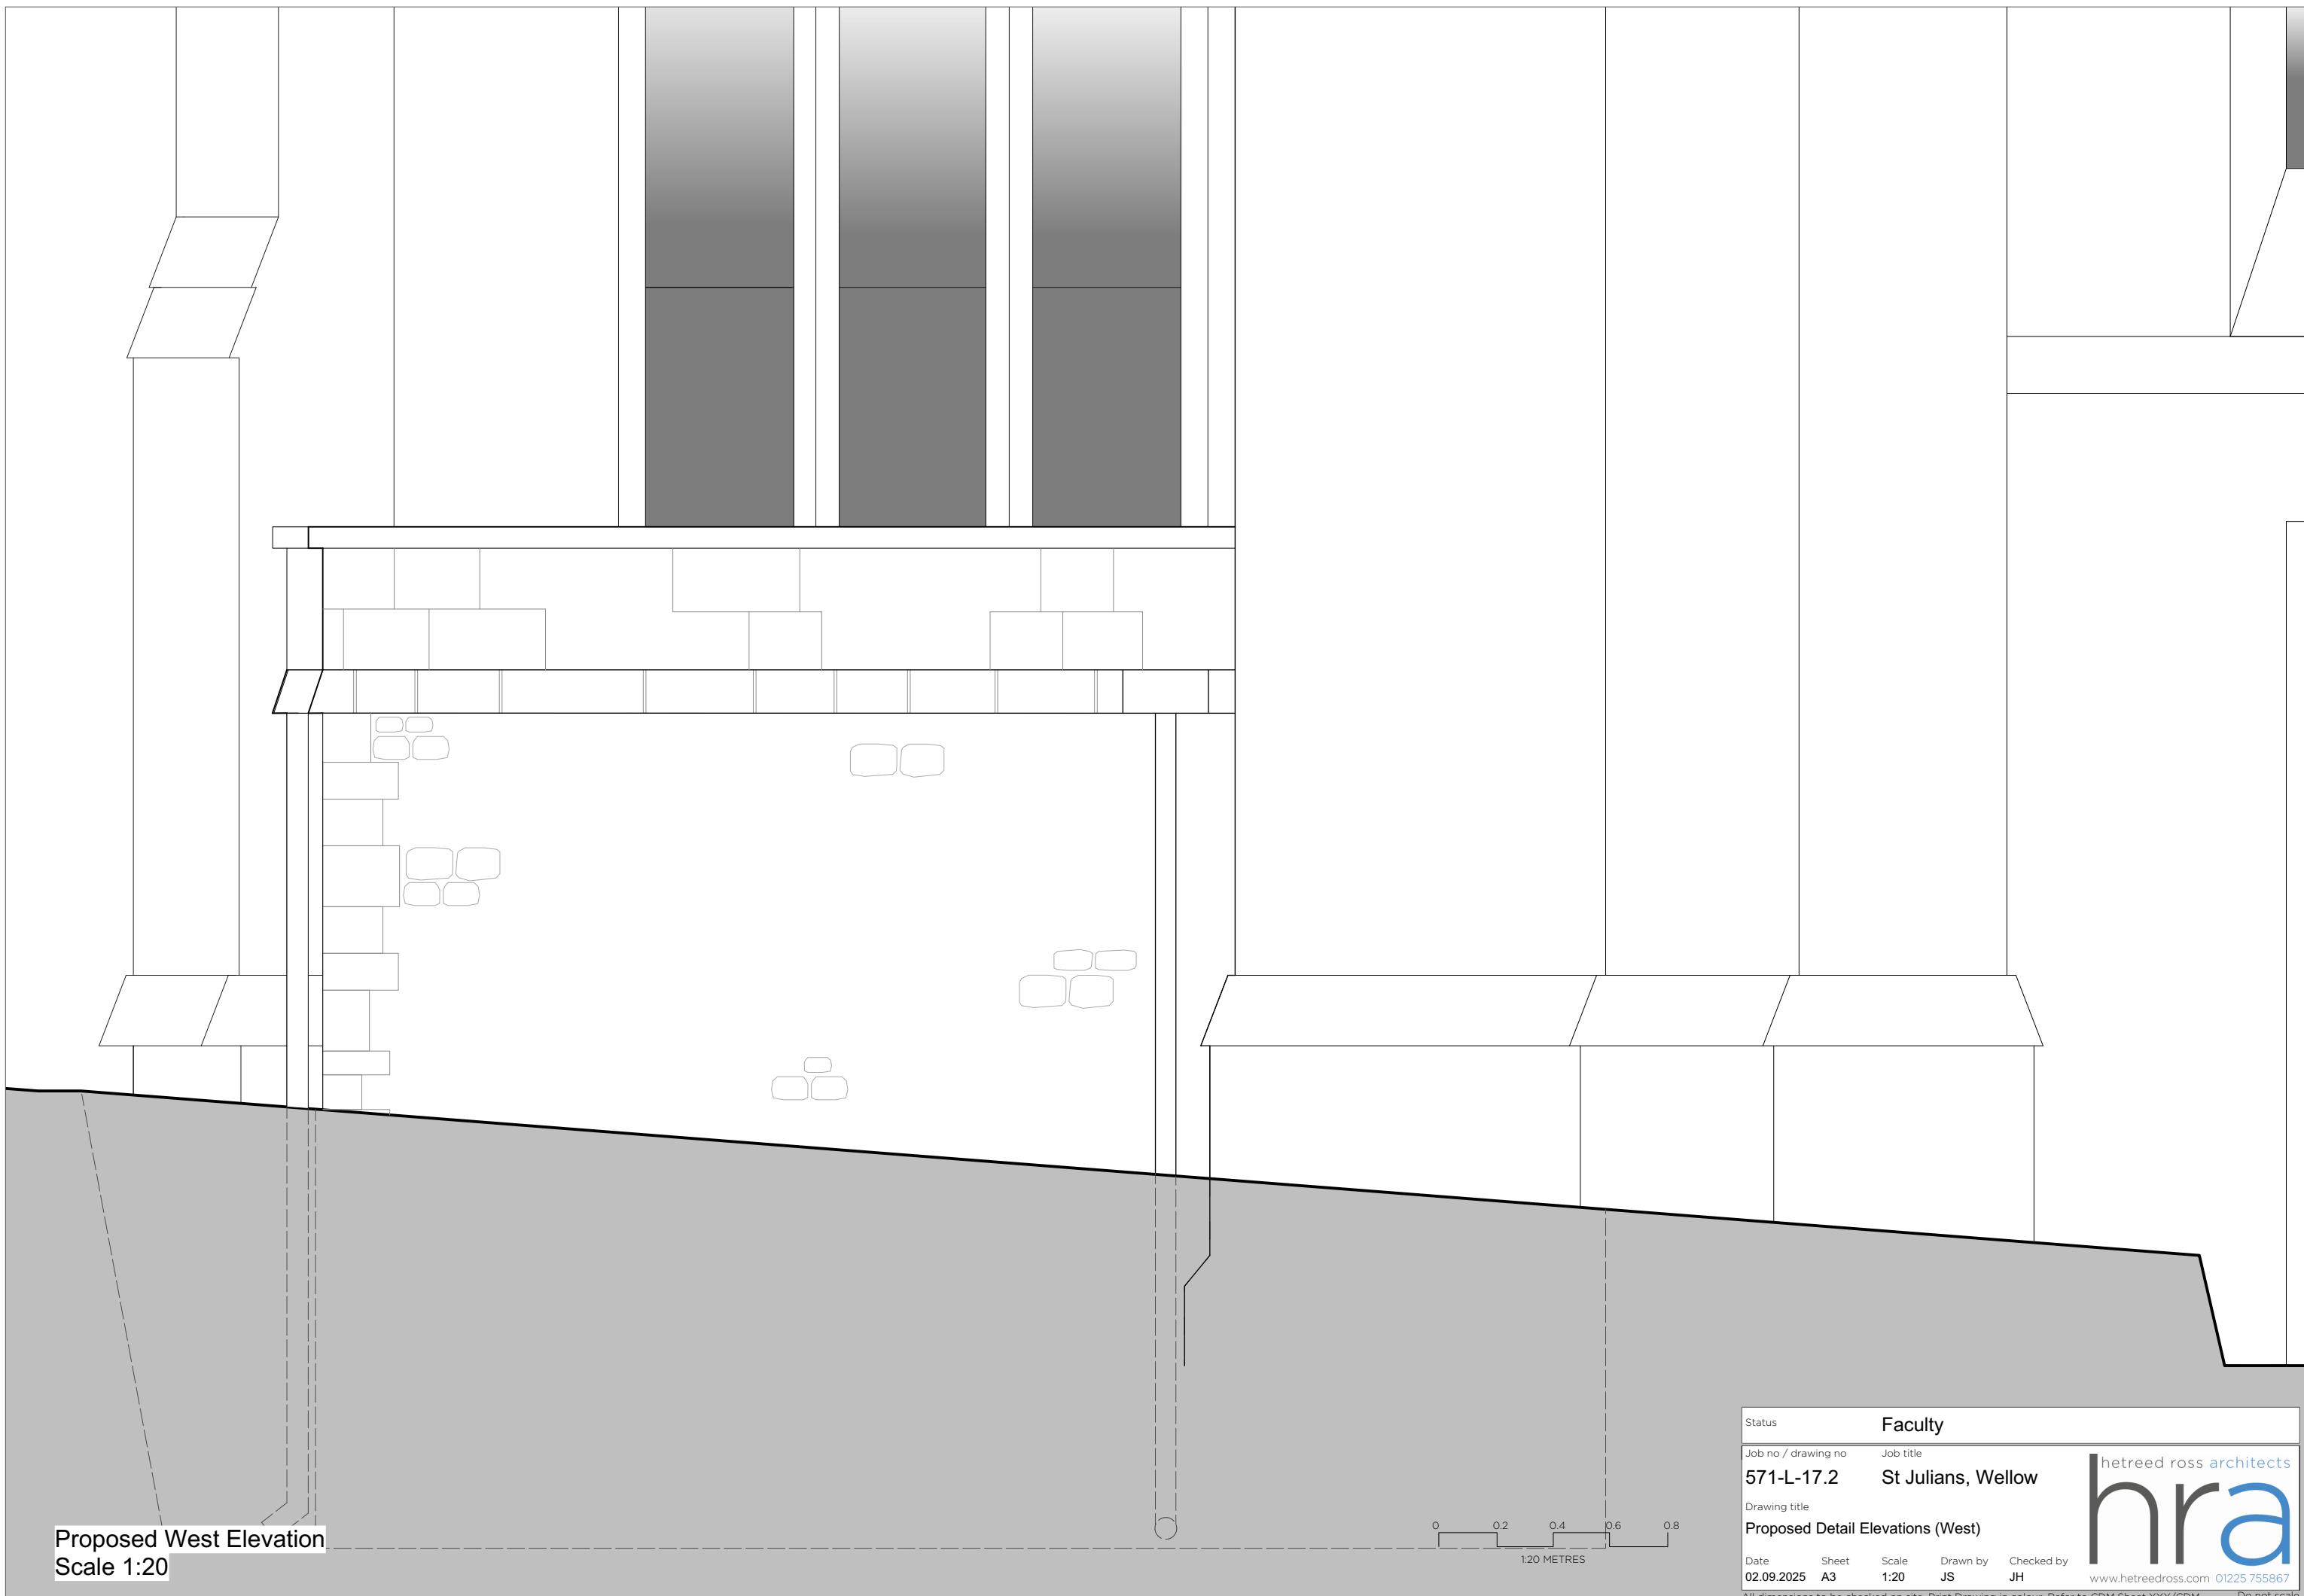

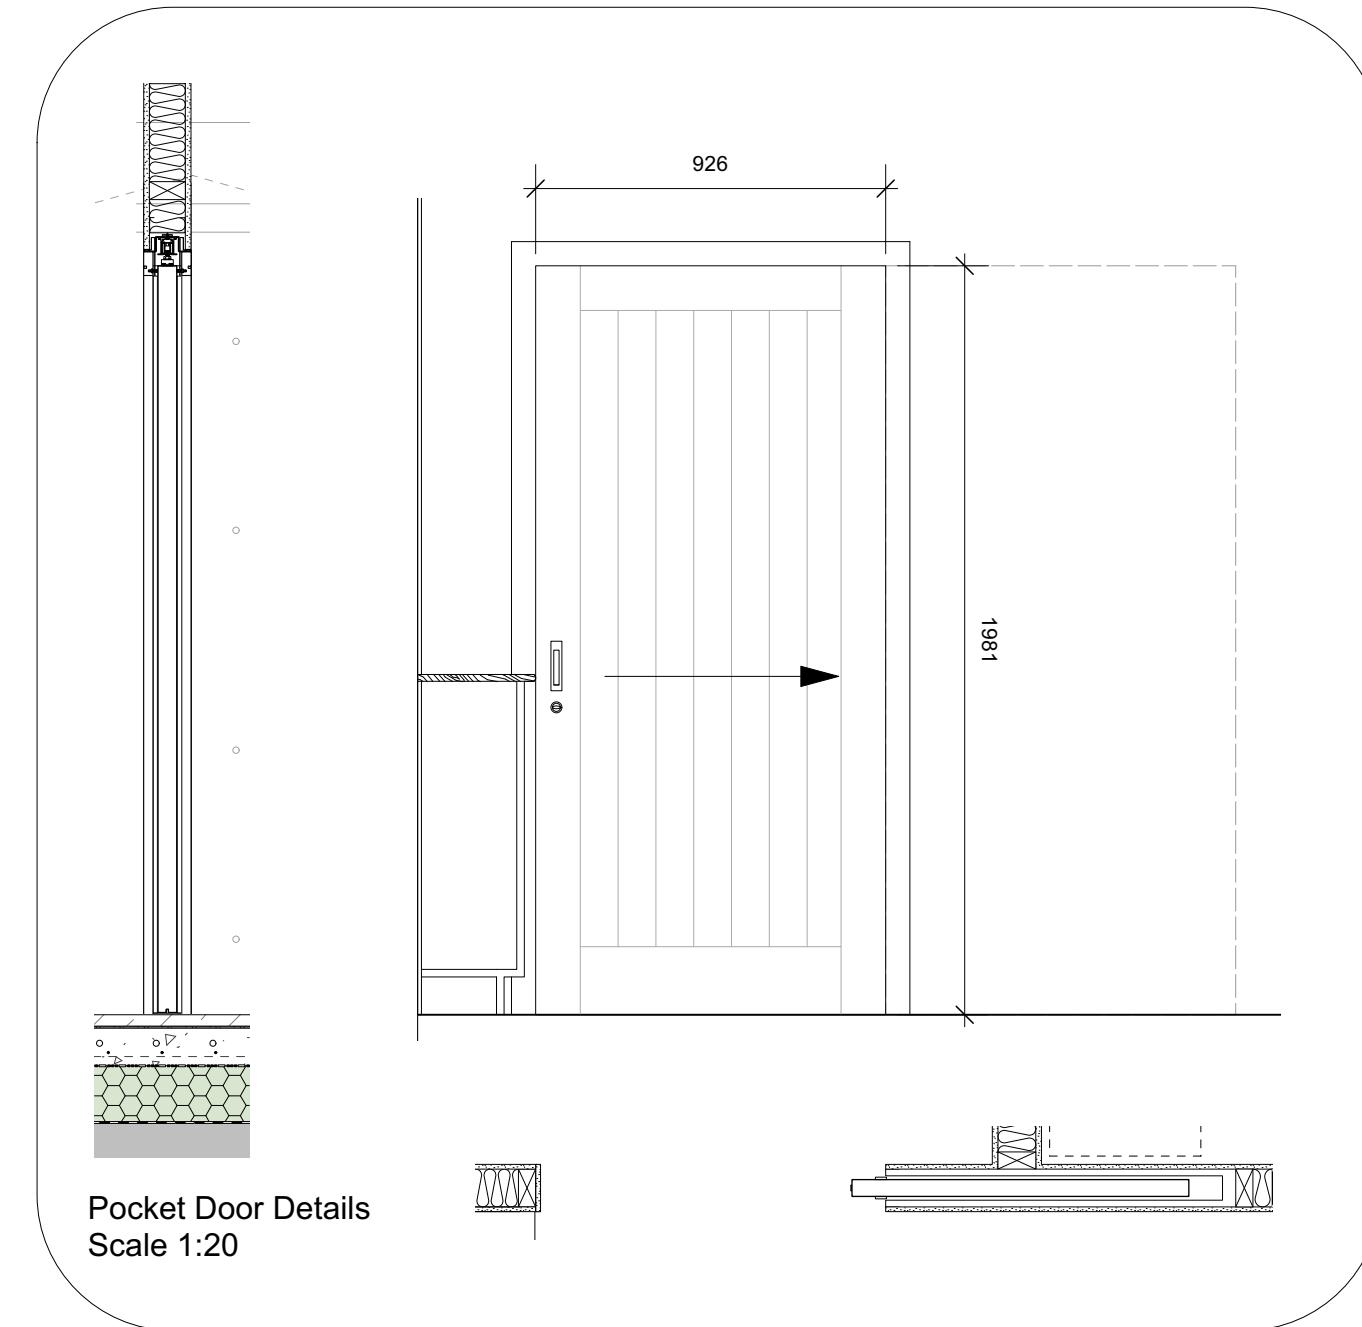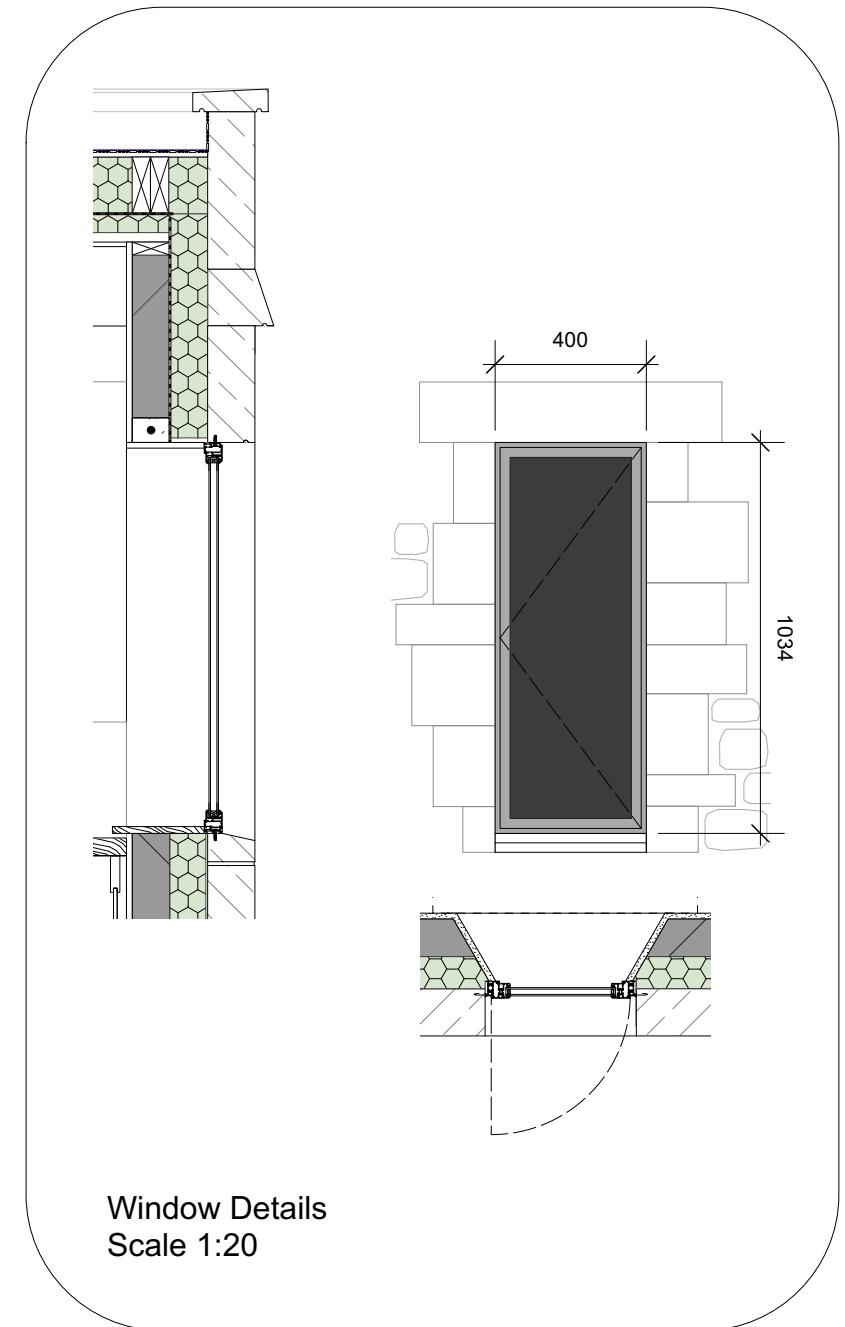


NOTE:  
Planning approved rooflight omitted from works

0 0.2 0.4 0.6 0.8  
1:20 METRES

Status	Faculty			
Job no / drawing no	Job title			
571-L-18.1	St Julians, Wellow			
Drawing title				
Proposed Joinery Details				
Date	Sheet	Scale	Drawn by	Checked by
02.09.2025	A3	1:20	JS	JH
All dimensions to be checked on site. Print Drawing in colour. Refer to CDM Sheet XXX/CDM				
www.hetreedross.com 01225 755867				
Do not scale				


hetreed ross architects  
**hra**  
www.hetreedross.com 01225 755867

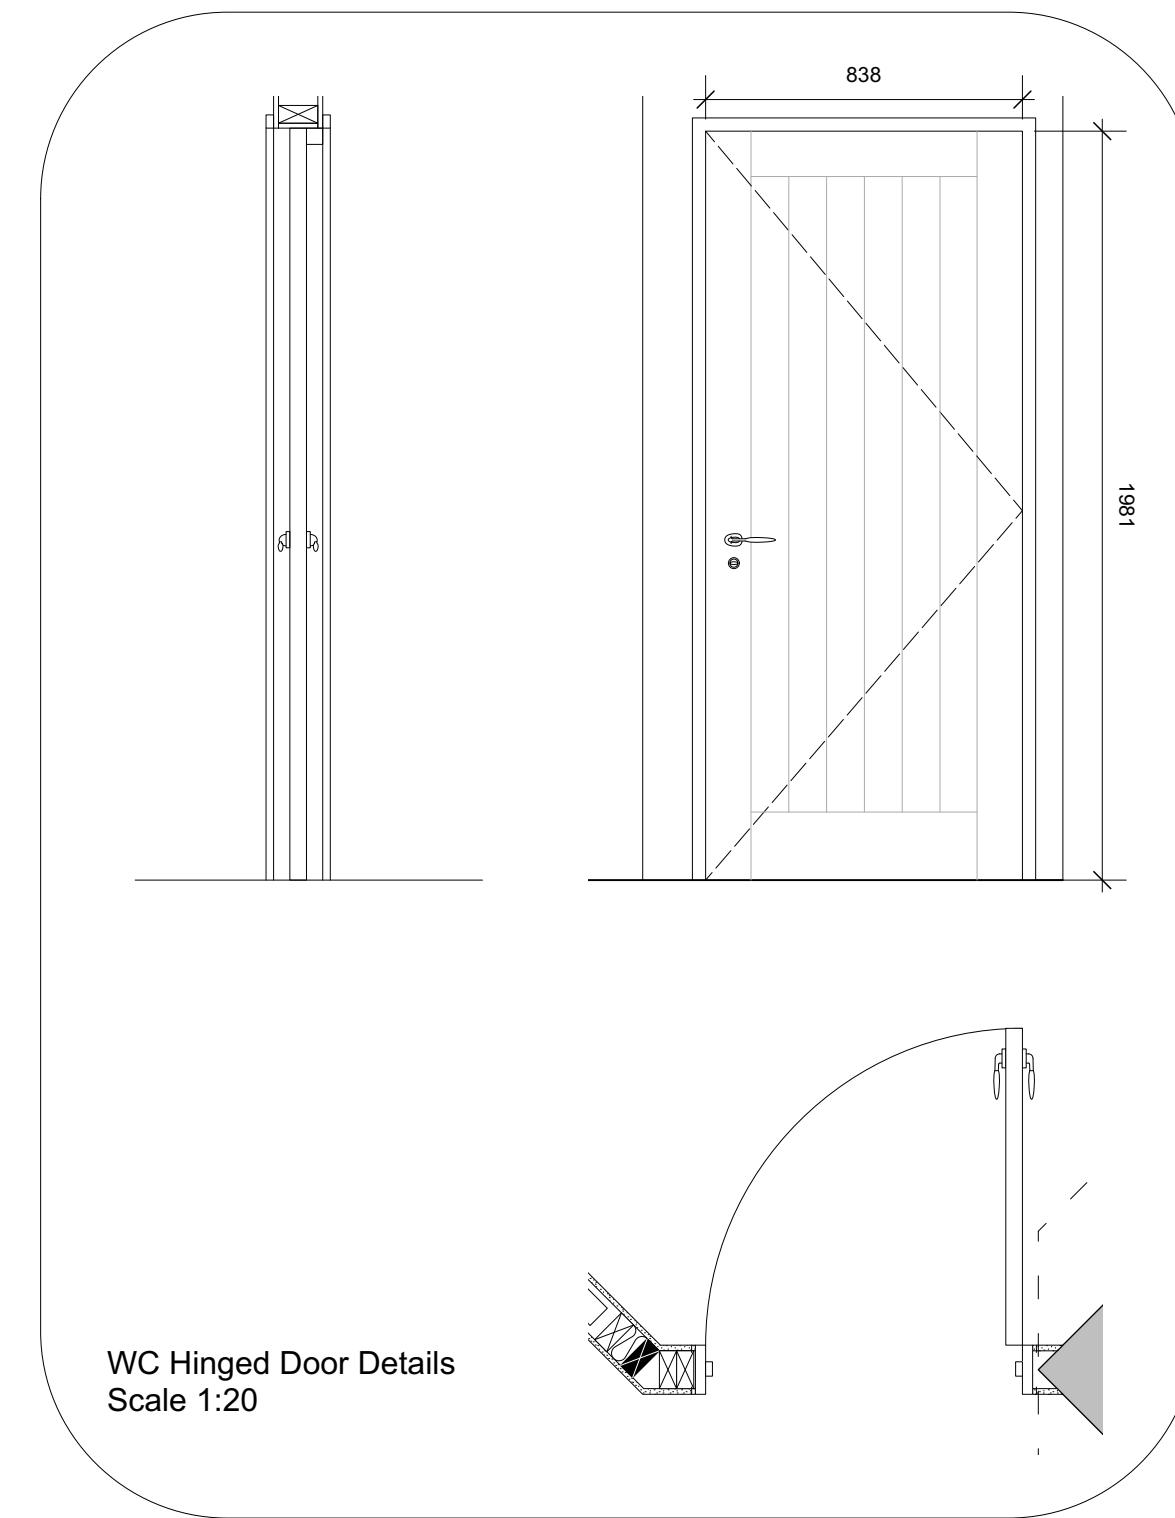


0 0.2 0.4 0.6 0.8  
1:20 METRES

Status	Faculty			
Job no / drawing no	Job title			
<b>571-L-18.2</b>	<b>St Julians, Wellow</b>			
Drawing title				
<b>Proposed Joinery Details</b>				
Date	Sheet	Scale	Drawn by	Checked by
02.09.2025	A3	1:20	JS	JH
All dimensions to be checked on site. Print Drawing in colour. Refer to CDM Sheet XXX/CDM				
www.hetreedross.com 01225 755867				
Do not scale				

hetreed ross architects  
**hra**

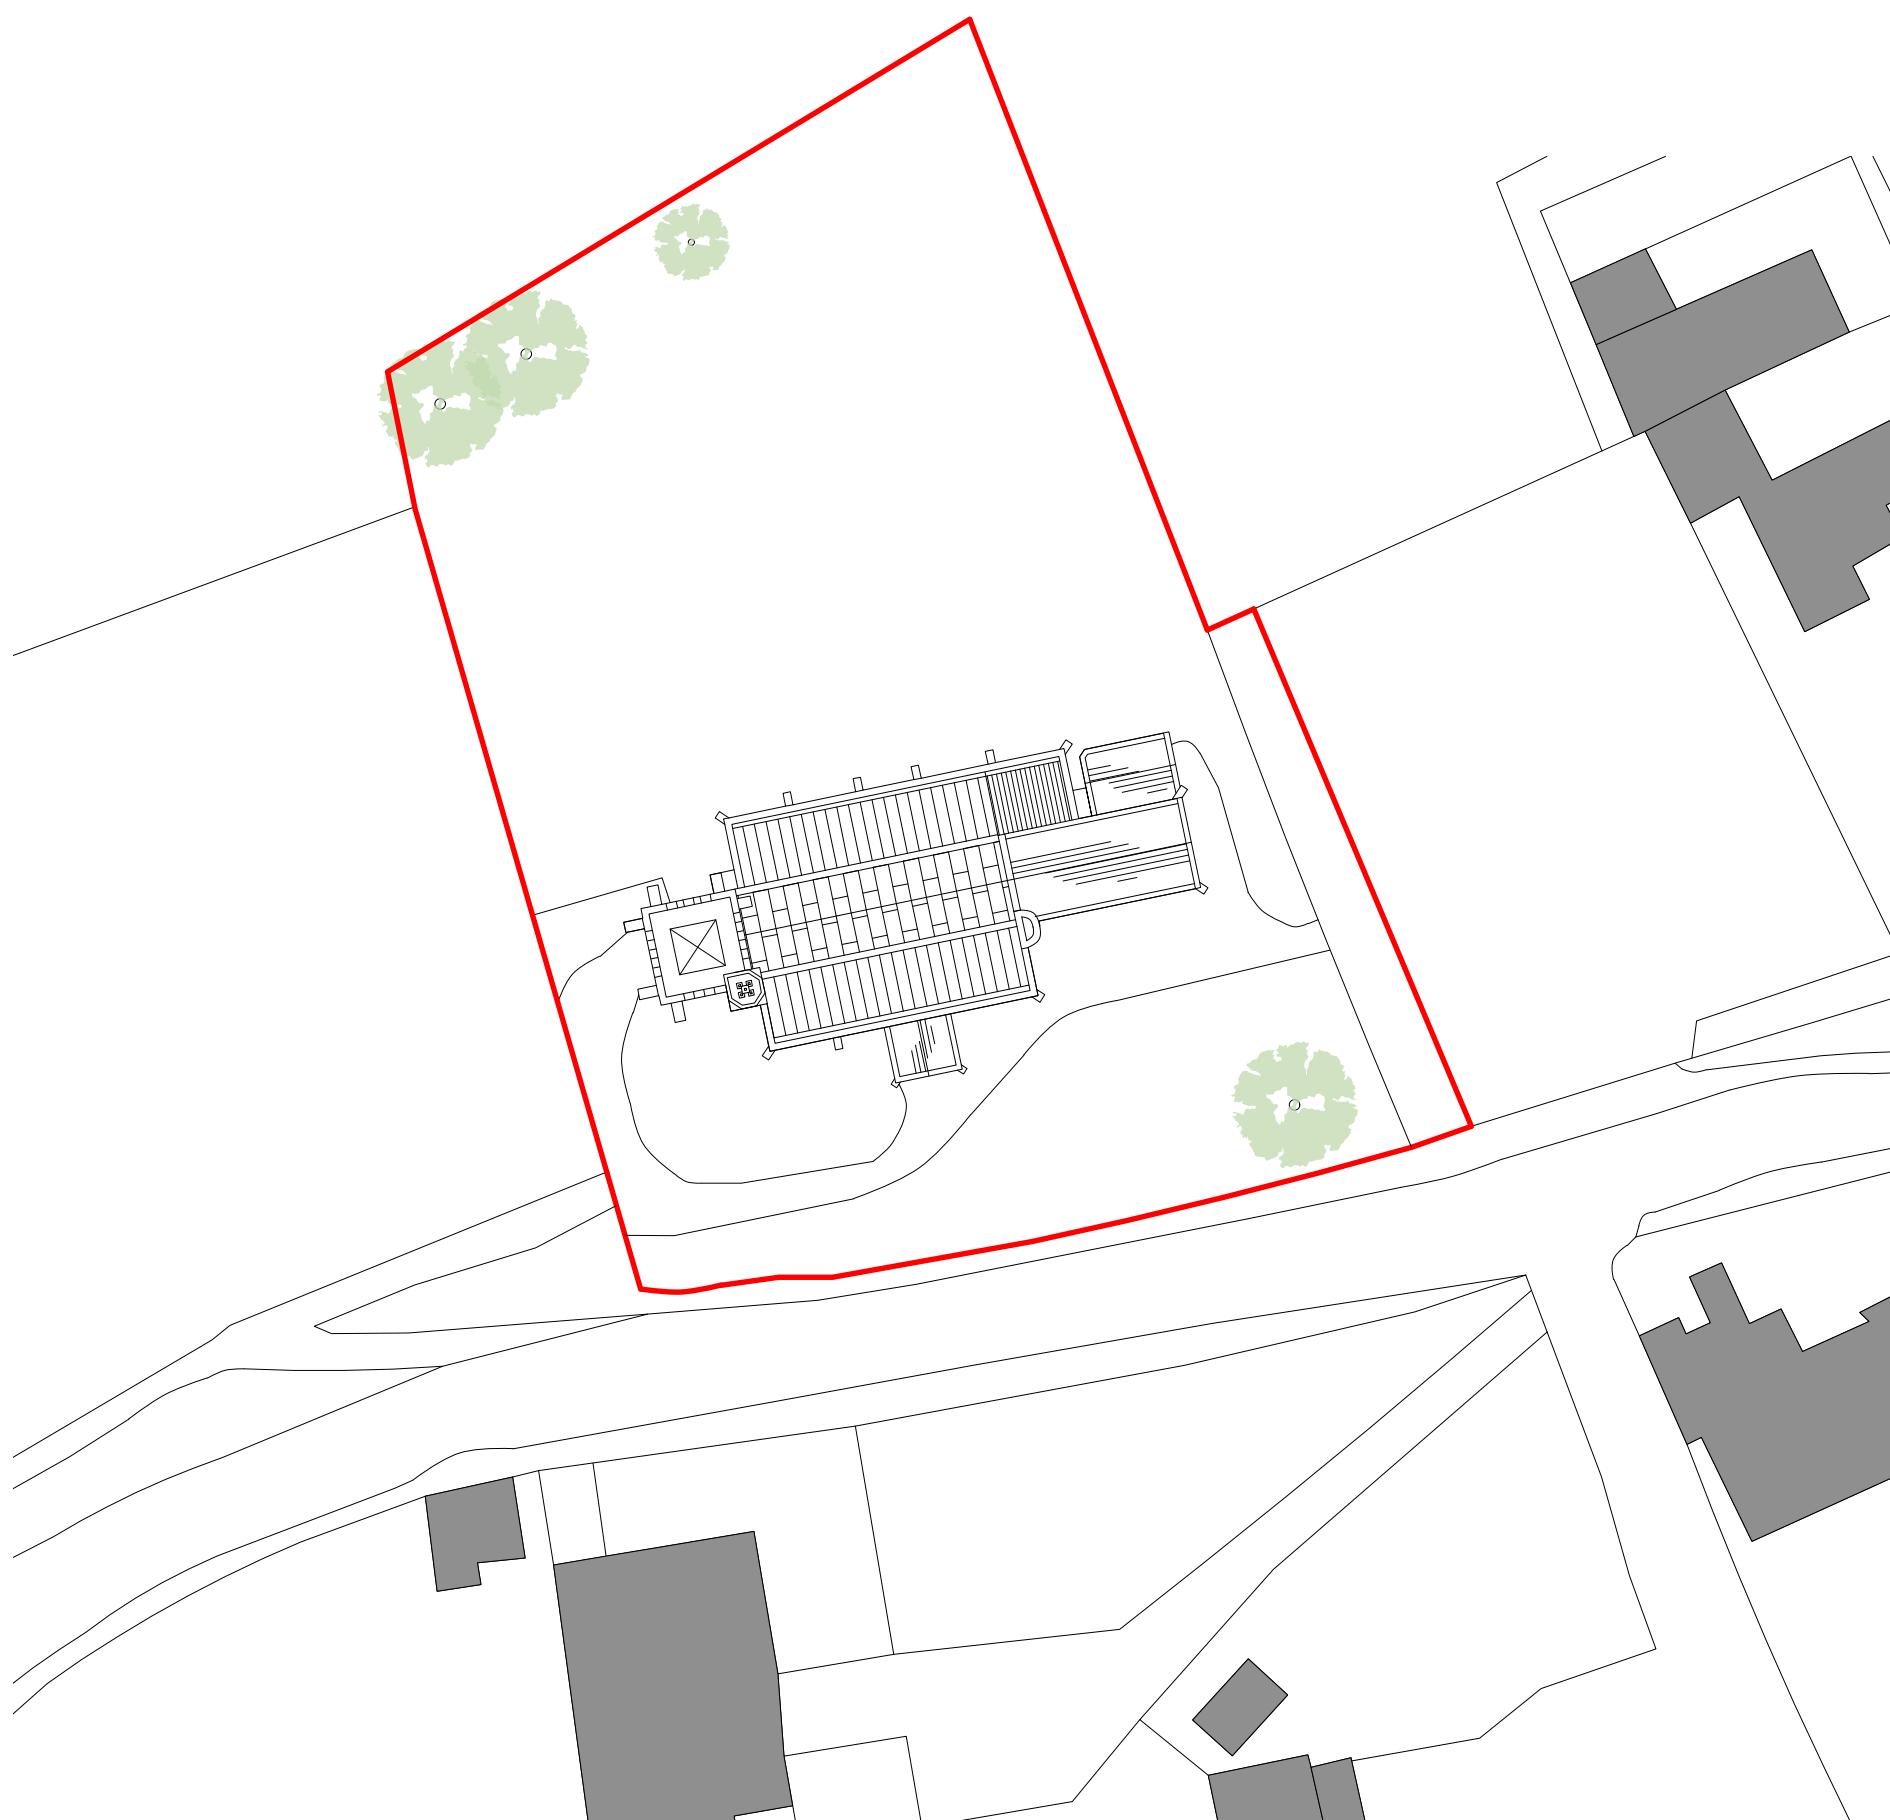

Site Plan 1:500

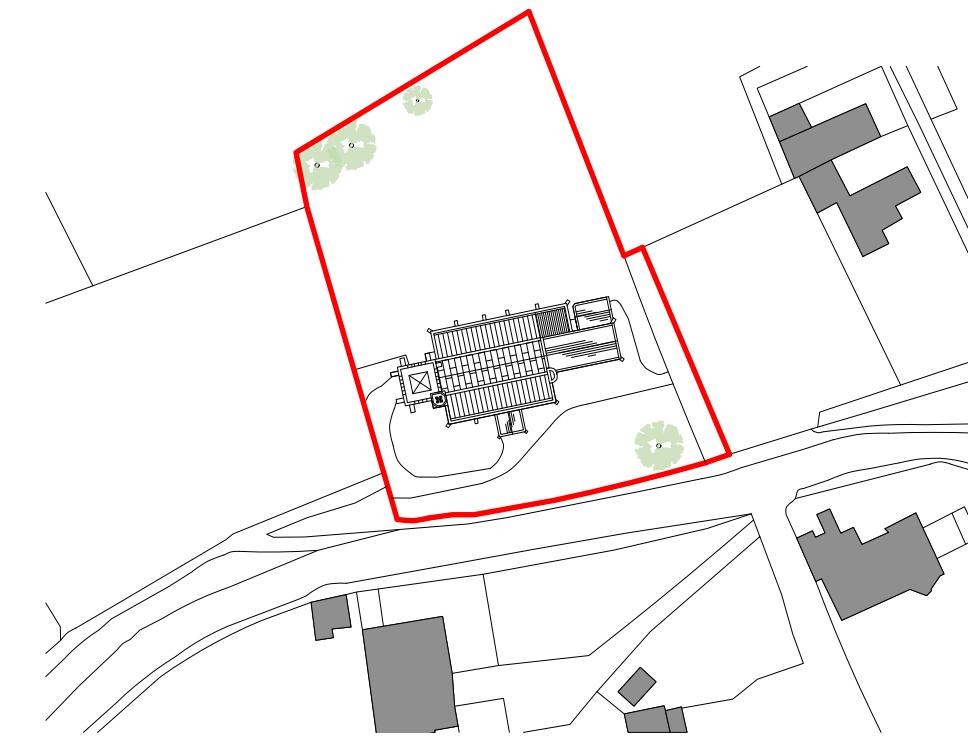


Location Plan 1:1250

0 5 10 15 20  
1:500 METRES

0 10 20 30 40 50  
1:1250 METRES

Status	Faculty
Job no / drawing no	Job title
<b>571-S-01A</b>	<b>St Julians, Wellow</b>
Drawing title	
<b>Site and Location plan</b>	
Date	Sheet
08-11-17	A3
Scale	Drawn by
1:500	Checked by
MS	JH
All dimensions to be checked on site. Print Drawing in colour. Refer to CDM Sheet XXX/CDM	
www.hetreedross.com 01225 755867	
Do not scale	



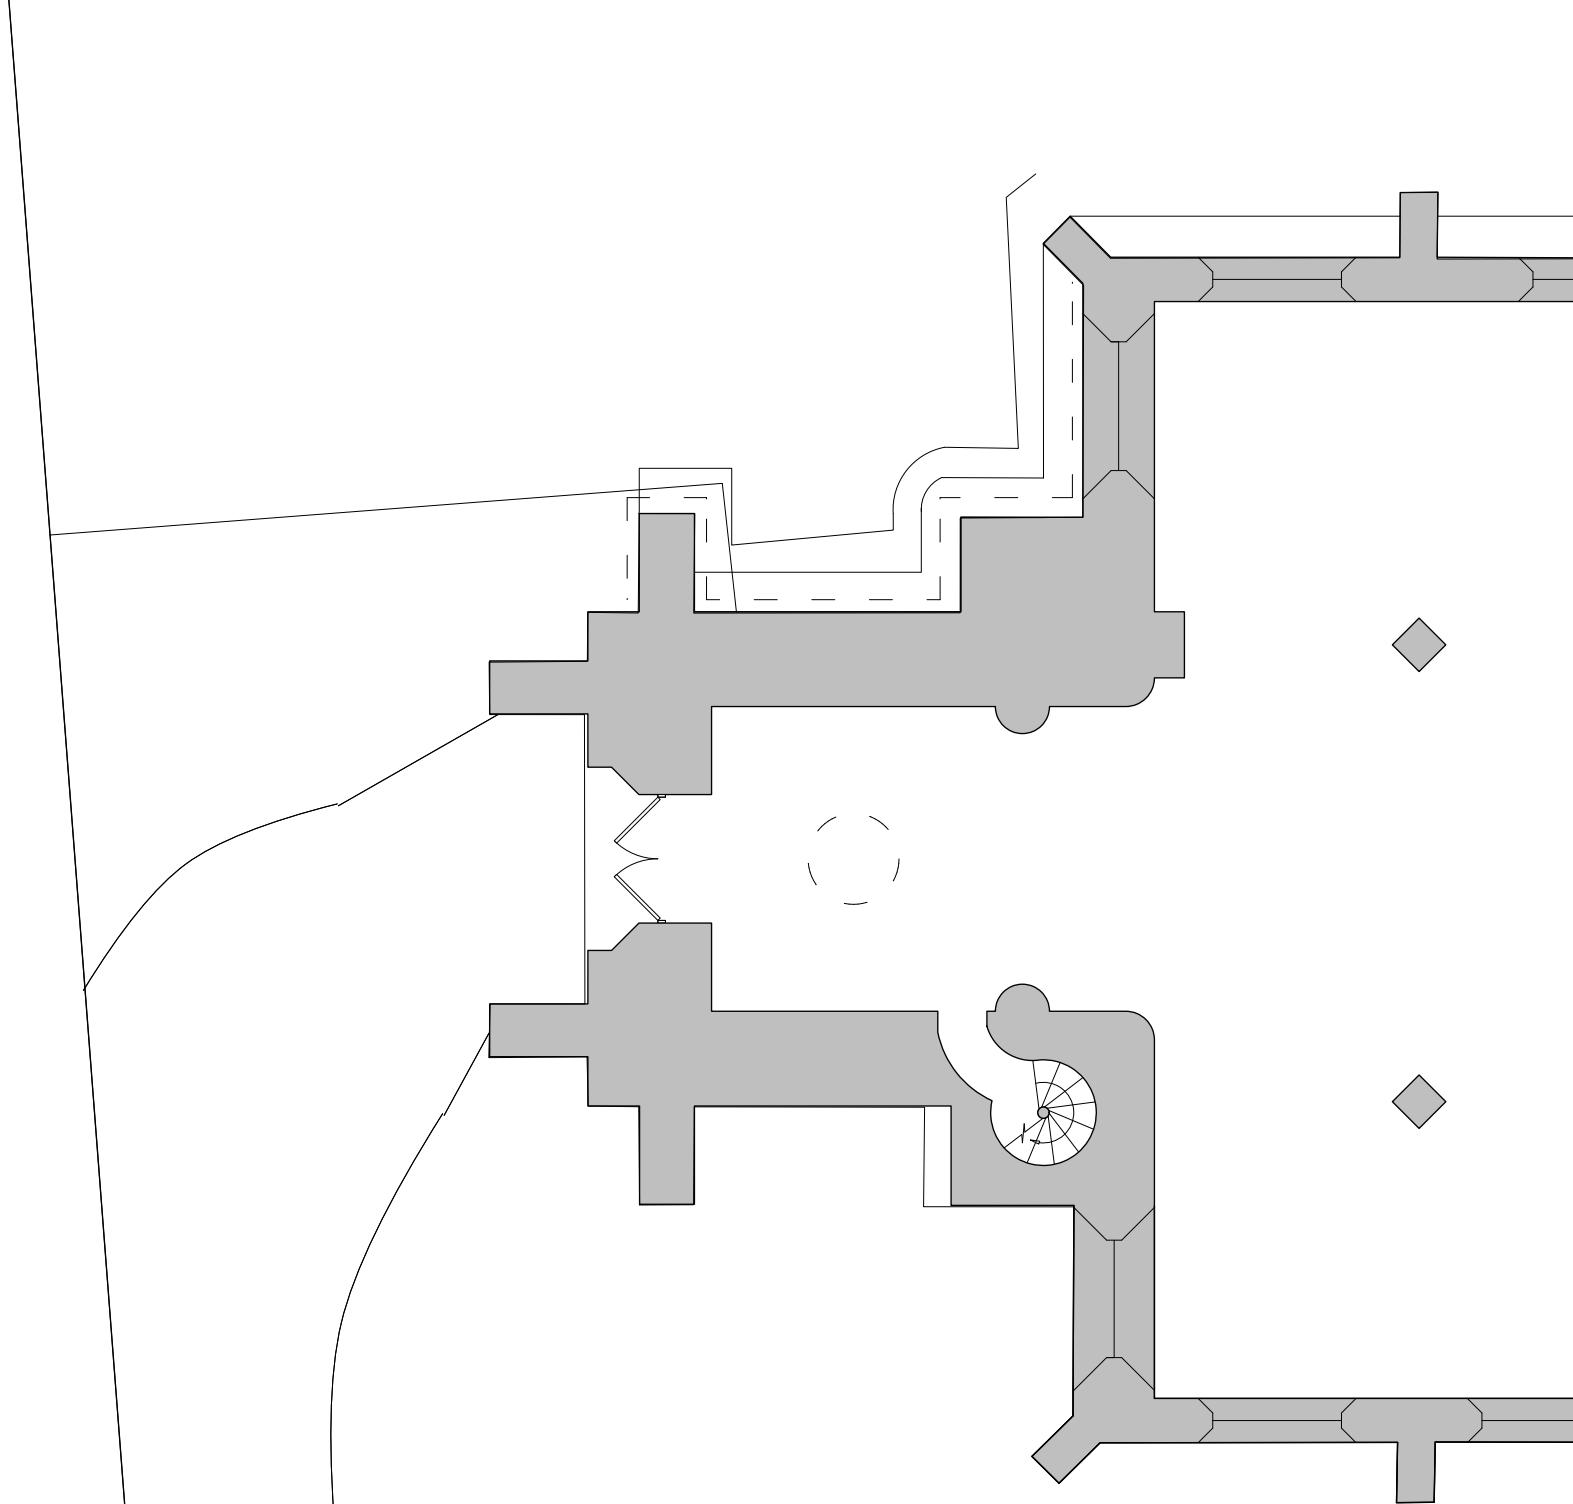


0 1 2 3 4  
1:100 METRES

AMENDMENT: A:		DATE 00.00.00		
Status	Faculty			
Job no / drawing no	Job title			
<b>571-S-02</b>	<b>St Julians, Wellow</b>	<b>hetreed ross architects</b>		
Drawing title				
<b>Existing ground floor plan</b>				
Date 08-11-17	Sheet A3	Scale 1:100	Drawn by MS	Checked by JH
All dimensions to be checked on site. Print Drawing in colour. Refer to CDM Sheet XXX/CDM				



**hra**  
hetreed ross architects  
www.hetreedross.com 01225 755867

Elevation approx 1:25

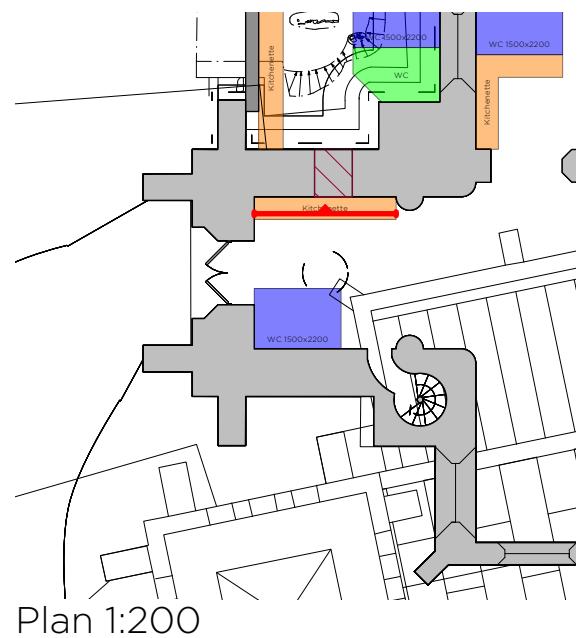

Plan 1:200

0 0.25 0.5 0.75 1.0  
1:25 METRES

0 2 4 6 8  
1:200 METRES

AMENDMENT:  
A:

DATE  
00.00.00

Status Faculty

Job no / drawing no

Job title

571-S-03

St Julians, Wellow

Drawing title

Photo survey- int. North tower elevation

Date

30/11/18

Sheet

A3

Scale

aprx 1:25

Drawn by

MS


Checked by


JH

hetreed ross architects  
**hra**  
www.hetreedross.com 01225 755867


All dimensions to be checked on site. Print Drawing in colour. Refer to CDM Sheet XXX/CDM

Do not scale


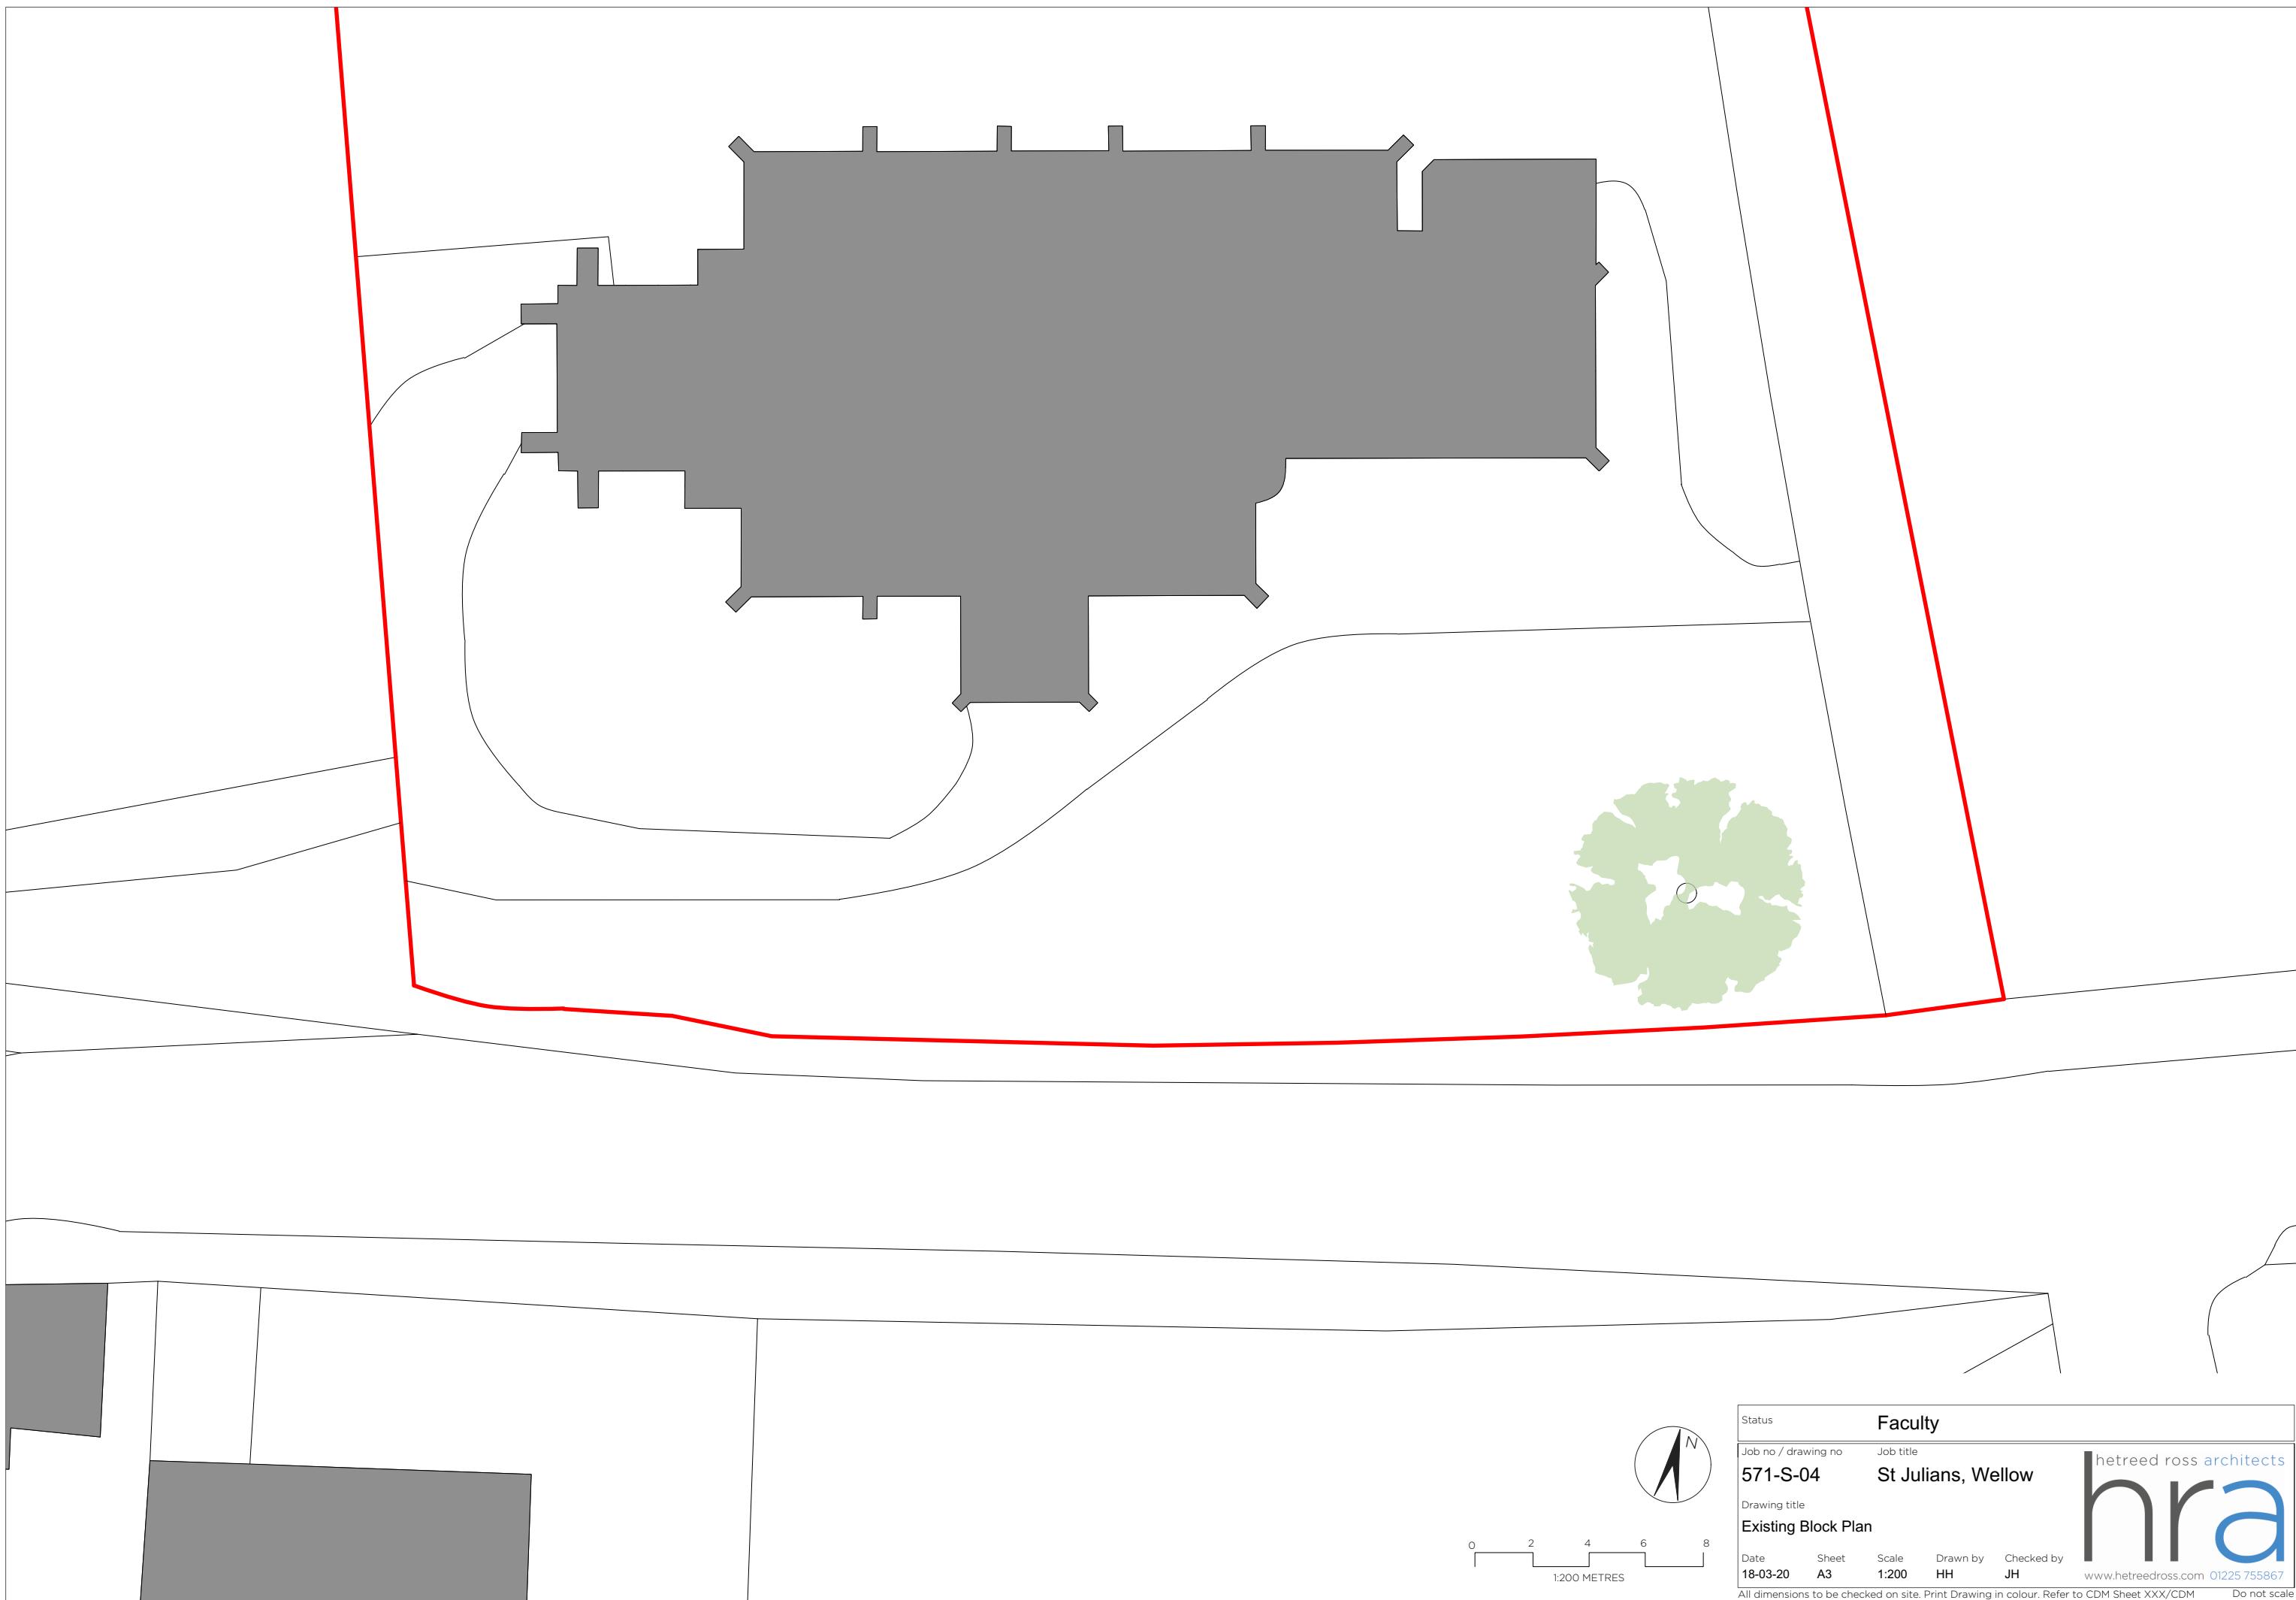


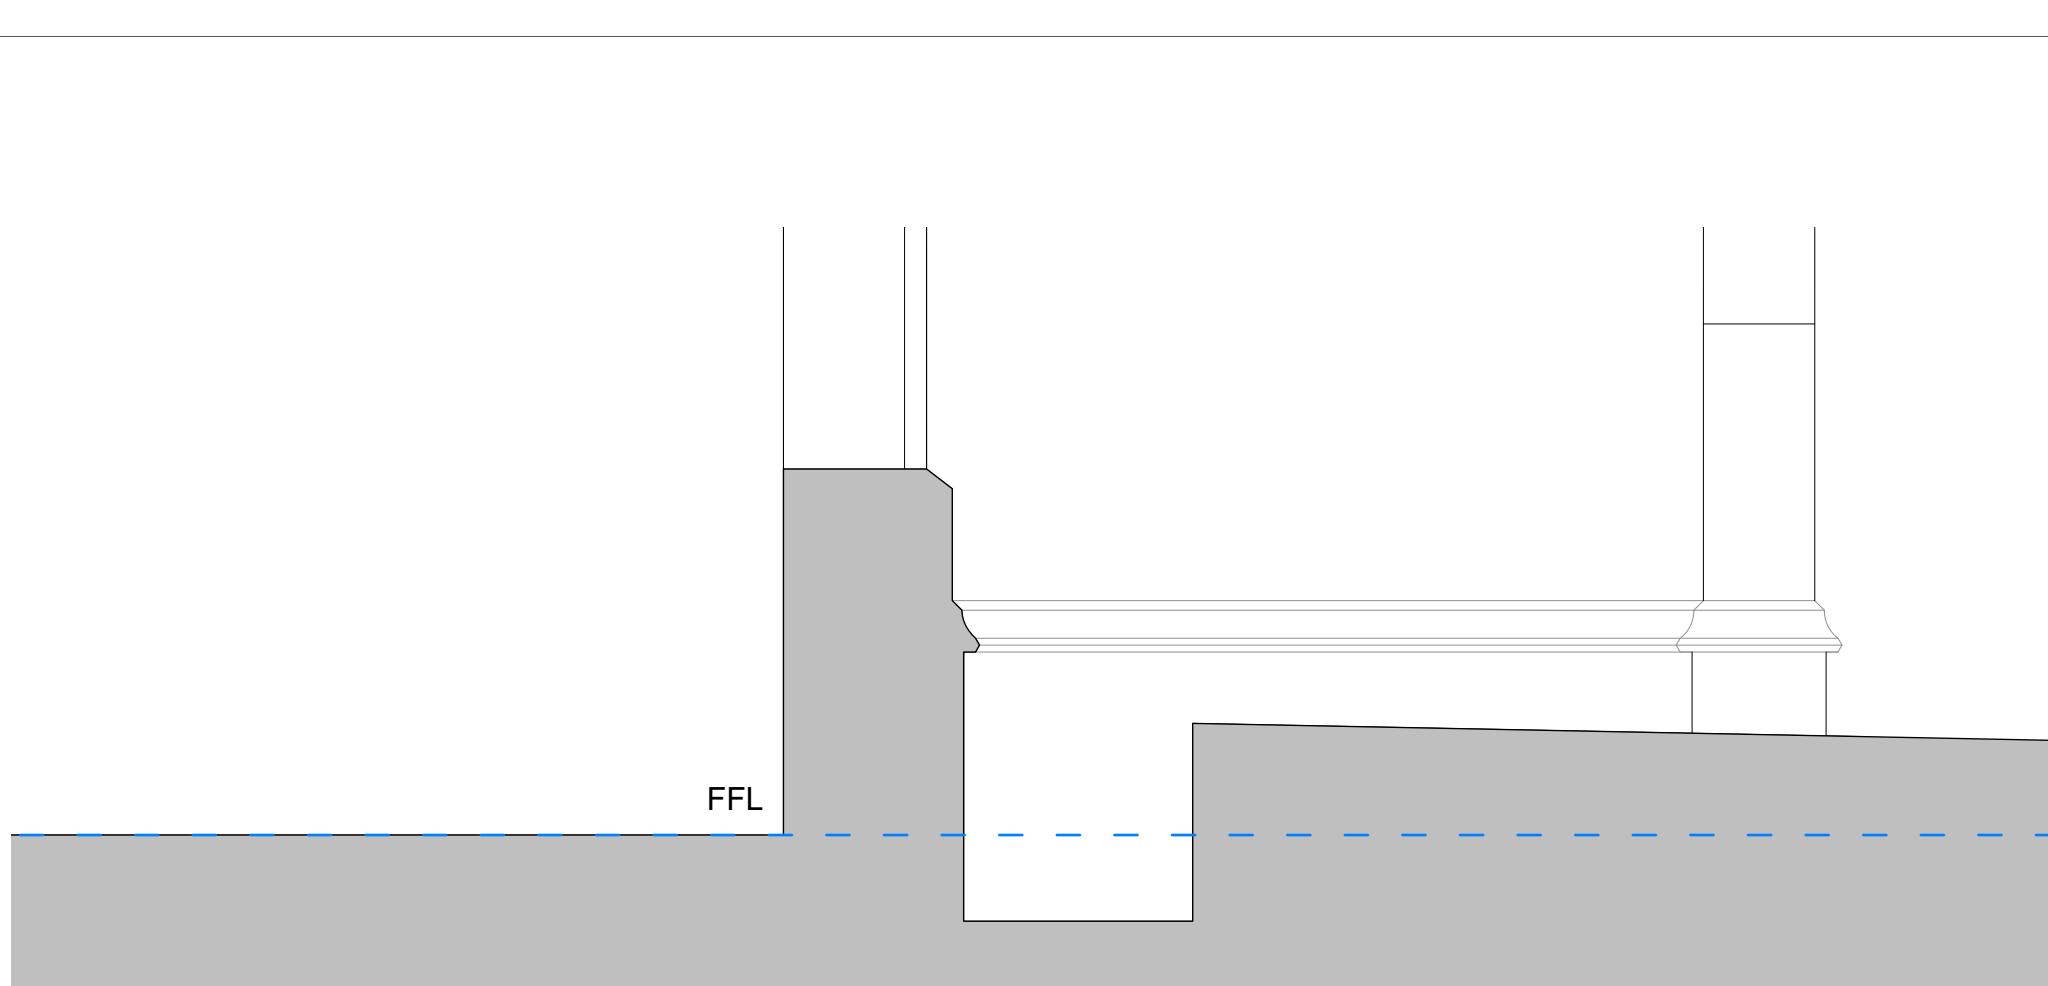

Existing Section AA

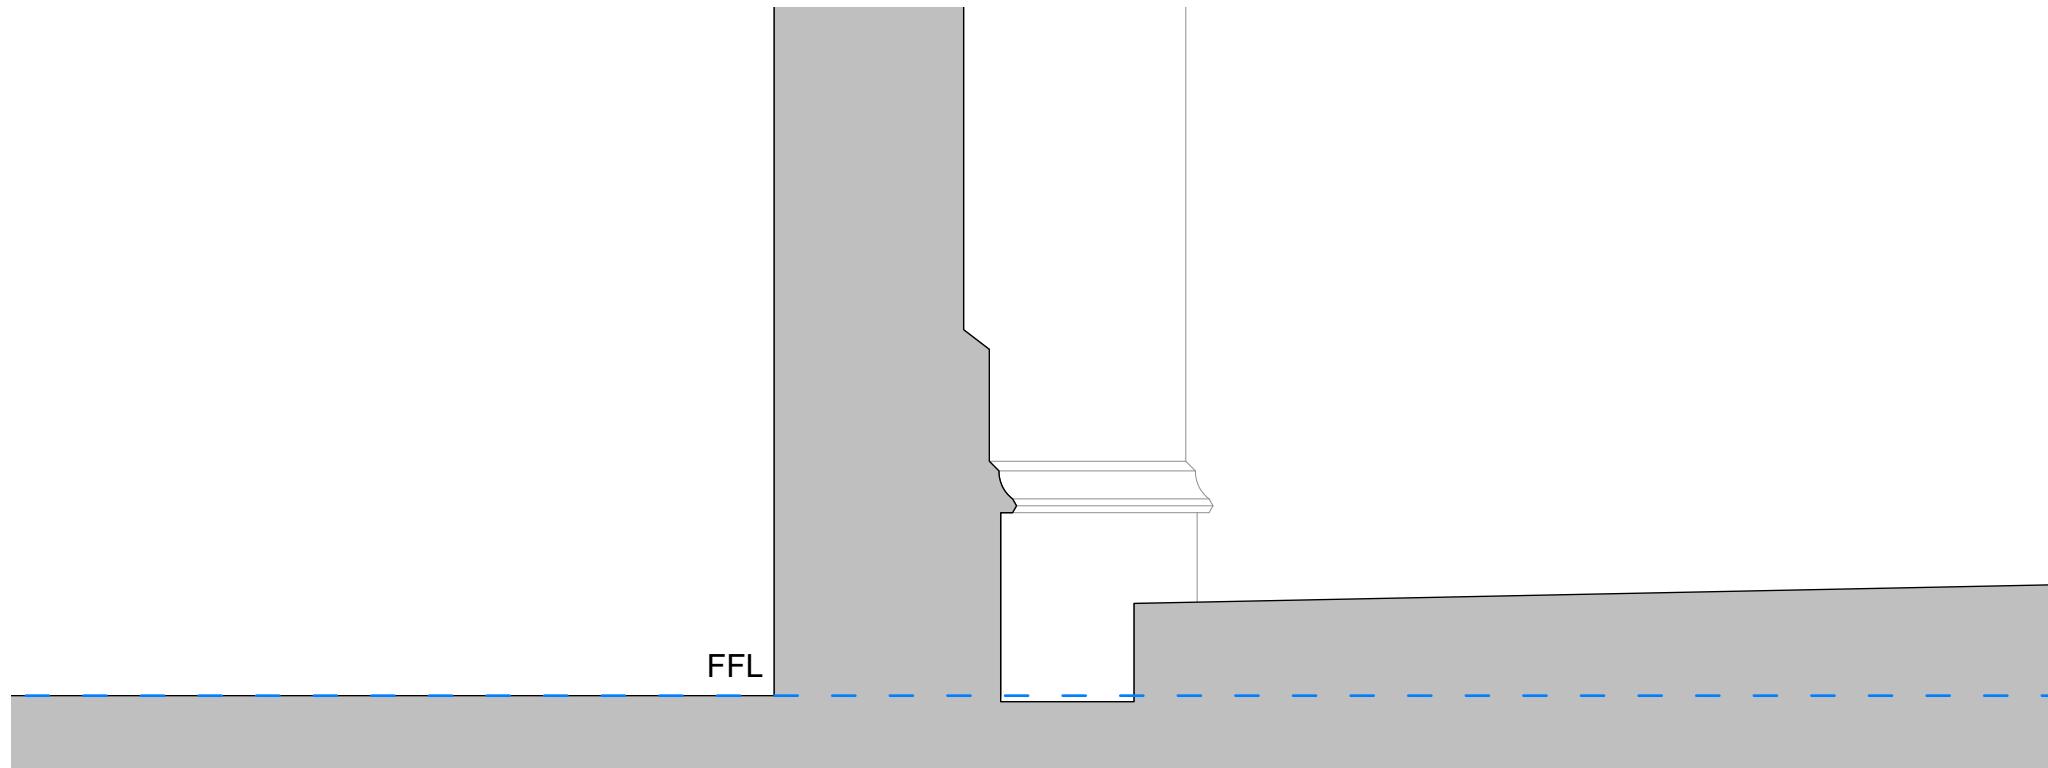

Existing Section BB

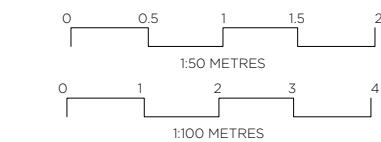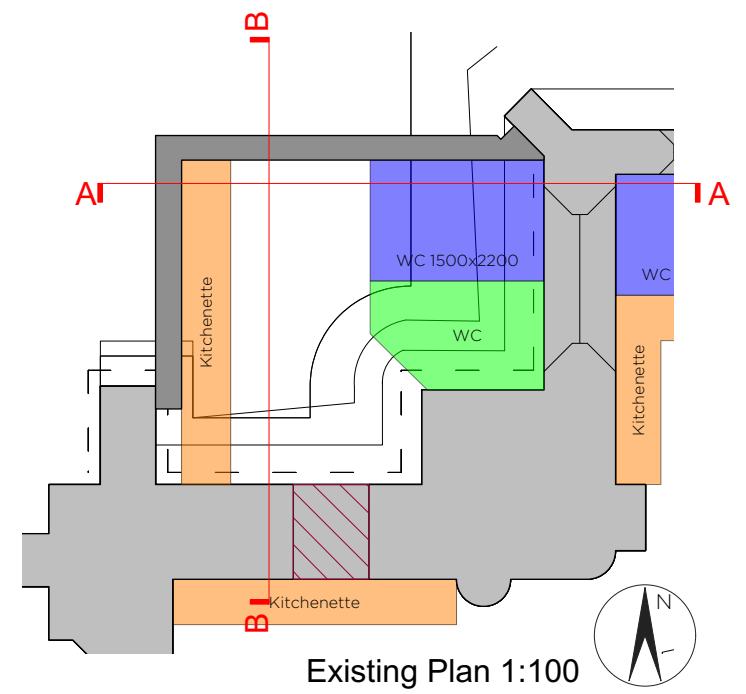

Status	Faculty
Job no / drawing no	Job title
571-S-05	St Julians, Wellow
Drawing title	
Existing Sections	
Date	Sheet
18-03-20	A3
Scale	Drawn by
1:50/ 100	JH
Checked by	JH
All dimensions to be checked on site. Print Drawing in colour. Refer to CDM Sheet XXX/CDM	
www.hetreedross.com 01225 755867	
Do not scale	



Existing North Elevation




Existing West Elevation

0 1 2 3 4  
1:100 METRES

Status	Faculty			
Job no / drawing no	Job title			
<b>571-S-06</b>	<b>St Julian's, Wellow</b>			
Drawing title				
<b>Existing Elevations</b>				
Date	Sheet	Scale	Drawn by	Checked by
18-03-20	A3	1:100	HH	JH
All dimensions to be checked on site. Print Drawing in colour. Refer to CDM Sheet XXX/CDM				
www.hetreedross.com 01225 755867				
Do not scale				

hetreed ross architects  
**hra**

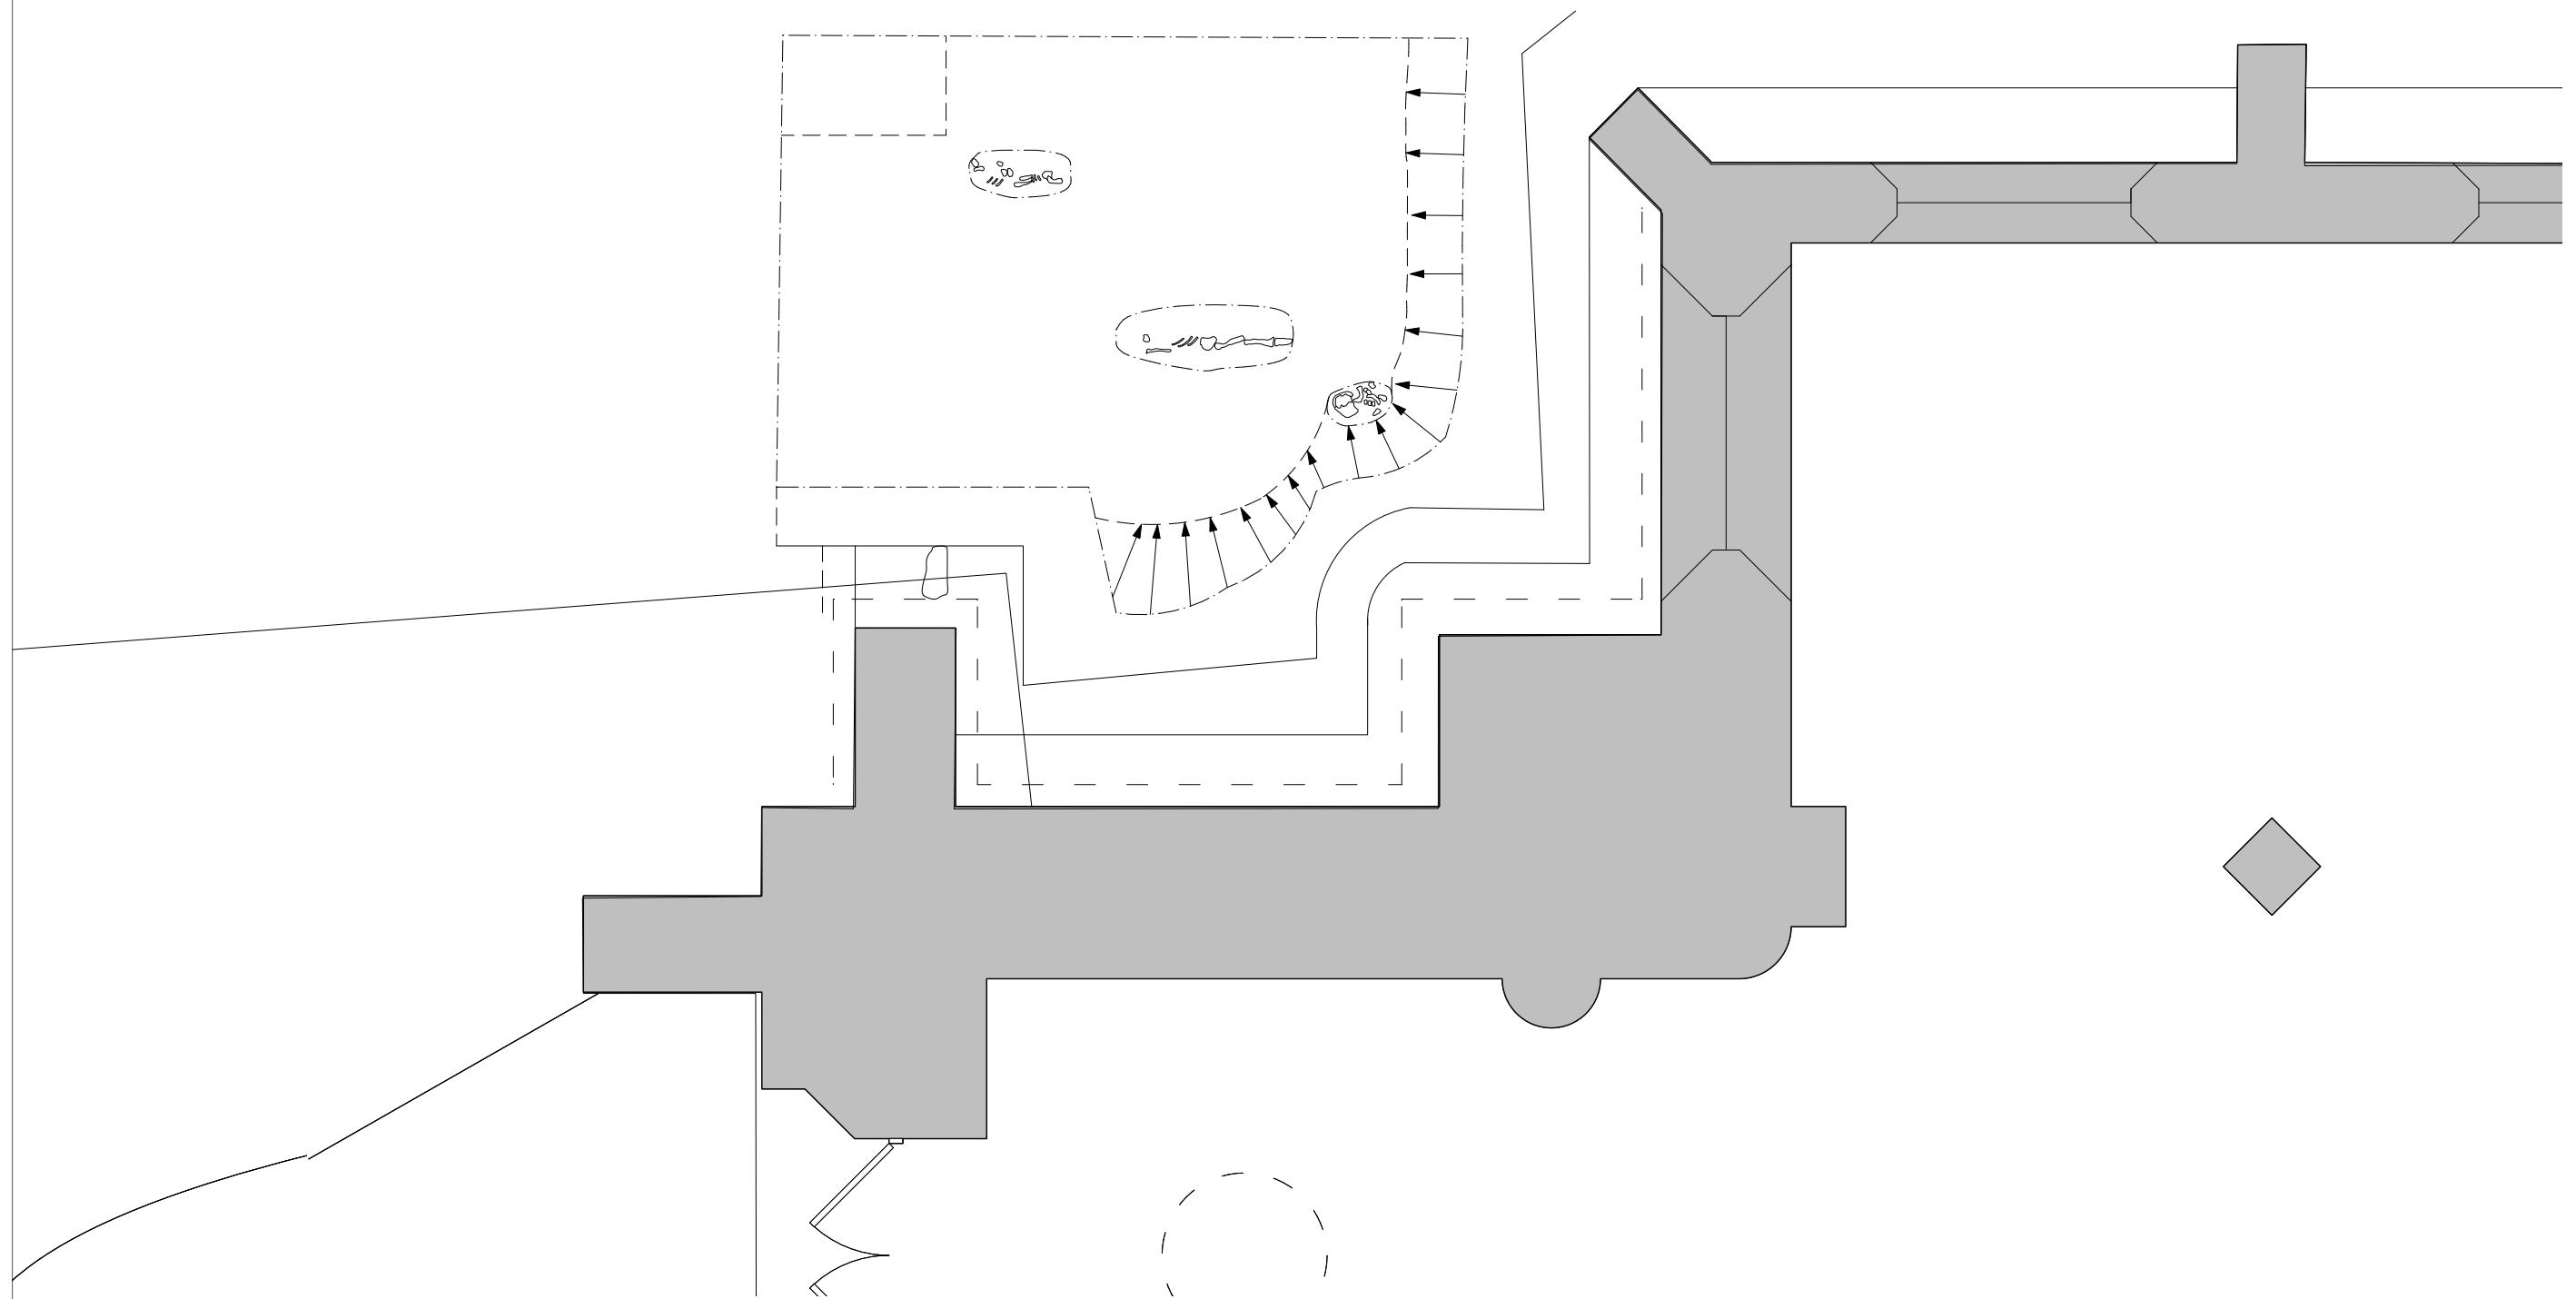

0 0.5 1 1.5 2  
1:50 METRES

AMENDMENT:  
A:

DATE  
00.00.00

Status	Faculty
Job no / drawing no	Job title
<b>571-S-07</b>	<b>St Julians, Wellow</b>
Drawing title	
Archaeological Survey	
Date	Sheet
08-11-17	A3
Scale	Drawn by
1:50	Checked by
	JS
	JH

hetreed ross architects  
**hra**  
www.hetreedross.com 01225 755867

All dimensions to be checked on site. Print Drawing in colour. Refer to CDM Sheet XXX/CDM Do not scale